

RS

(A)


WITH PRE-PURCHASED ACTUATOR

(C

В			

	EXHAUST FAN SCHEDULE										
TAG	MANUFACTURER	MODEL	L/S (CFM)	ΔP Pa (IN WC)			ELECTRICAL	NOTES			
EF-1	PENN BARRY	DOMEX DX11R	270 (570)	62 (1⁄4)	1550	107	240/1φ	WALL MOUNTED			

	UNIT HEATER SCHEDULE									
TAG	MANUFACTURER	MODEL	kW	VOLTS	AIRFLOW L/S (CFM)	ΔT °C (°F)	NOTES			
UH-1	CALORITECH	GE	4	240	225 (475)	15.6 (28)	WALL MOUNTING BRACKET			
UH-2	CALORITECH	GE	4	240	225 (475)	15.6 (28)	WALL MOUNTING BRACKET			

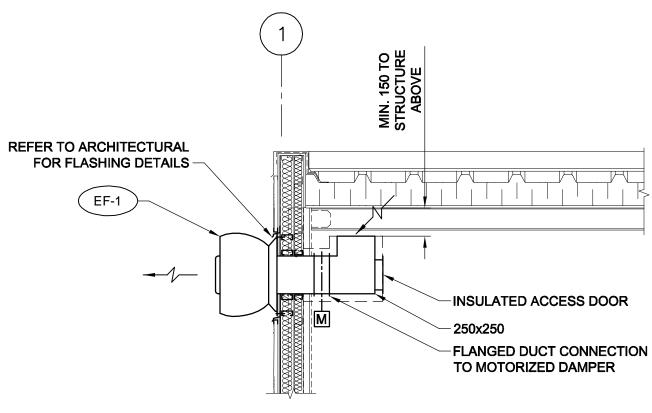




SECTION ______ mm SCALE 1:25 0 250 500 750



LOCATION APPROVED UNDERGROUND STRUCTURES						THIS DOCUMENT IS USED, REPRODUCI	ED OR MODIFIED IN A WITH THE WRITTEN	PYRIGHT LAW AND MAY NOT BE NY MANNER OR FOR ANY PERMISSION OF UMA	PROFESSIONAL'S S
SUPR. U/G STRUCTURES DATE COMMITTEE						RESPONSIBILITY, A PARTY THAT USES	ENGINEERING LTD. DOING BUSINESS AS AECOM ("AECOM") OR A PARTY TO WHICH ITS COPYRIGHT HAS BEEN ASSIGNED. AECOM ACCEPTS NO RESPONSIBILITY, AND DENIES ANY LIABILITY WHATSOEVER, TO ANY PARTY THAT USES, REPRODUCES, MODIFIES, OR RELIES ON THIS DOCUMENT WITHOUT AECOM'S EXPRESS WRITTEN CONSENT.		Revision
NOTE: LOCATION OF UNDERGROUND STRUCTURES AS SHOWN ARE BASED ON THE BEST					DESIGNED BY	JB	CHECKED BY	BP	WAS SEALE C. A. D. COUR
INFORMATION AVAILABLE. BUT NO GUARANTEE IS GIVEN THAT ALL EXISTING UTILITIES ARE SHOWN OR THAT THE GIVEN					DRAWN BY	ALS	APPROVED BY	Bryan Weber	AND DAT
LOCATIONS ARE EXACT. CONFIRMATION OF EXISTENCE AND EXACT LOCATION OF ALL					HOR. SCALE	1:50	RELEASED CONSTRUC		CONSULTANT DR/
SERVICES MUST BE OBTAINED FROM THE INDIVIDUAL UTILITIES BEFORE PROCEEDING	0	ISSUED FOR CONSTRUCTION	09/04/29	ALS	VERT. SCALE	-		Linda Hoehn	
WITH CONSTRUCTION.	NO.	REVISIONS	YY/MM/DD	BY	DATE 09	9/04/30	DATE	09/04/30	D265-236-00_01-M-0

 LEGEND



---- MOTORIZED DAMPER

FIRE EXTINGUISHER

---- CONTROL WIRING

LINE VOLTAGE WIRING

THERMOSTAT

OUTDOOR AIR TEMPERATURE SENSOR



