TEL:(204) 925-1150

**LEGEND** 

SECURITY SYSTEM SPEAKER

NURSE CALL SYSTEM PULL STATION

NURSE CALL SYSTEM DOME LIGHT



4TH FLOOR - 185 KING STREET R3B 1J1 Project: **Mayfair Recreation** 

Centre


Winnipeg, MB Bid Opportunity Number: 556-2012 Drawing Title:


ELECTRICAL SITE PLAN

# Issue/Revision Date

66% REISSUE REVIEW 99% REVIEW ISSUED FOR TENDER 2013-04-12

Sheet No:

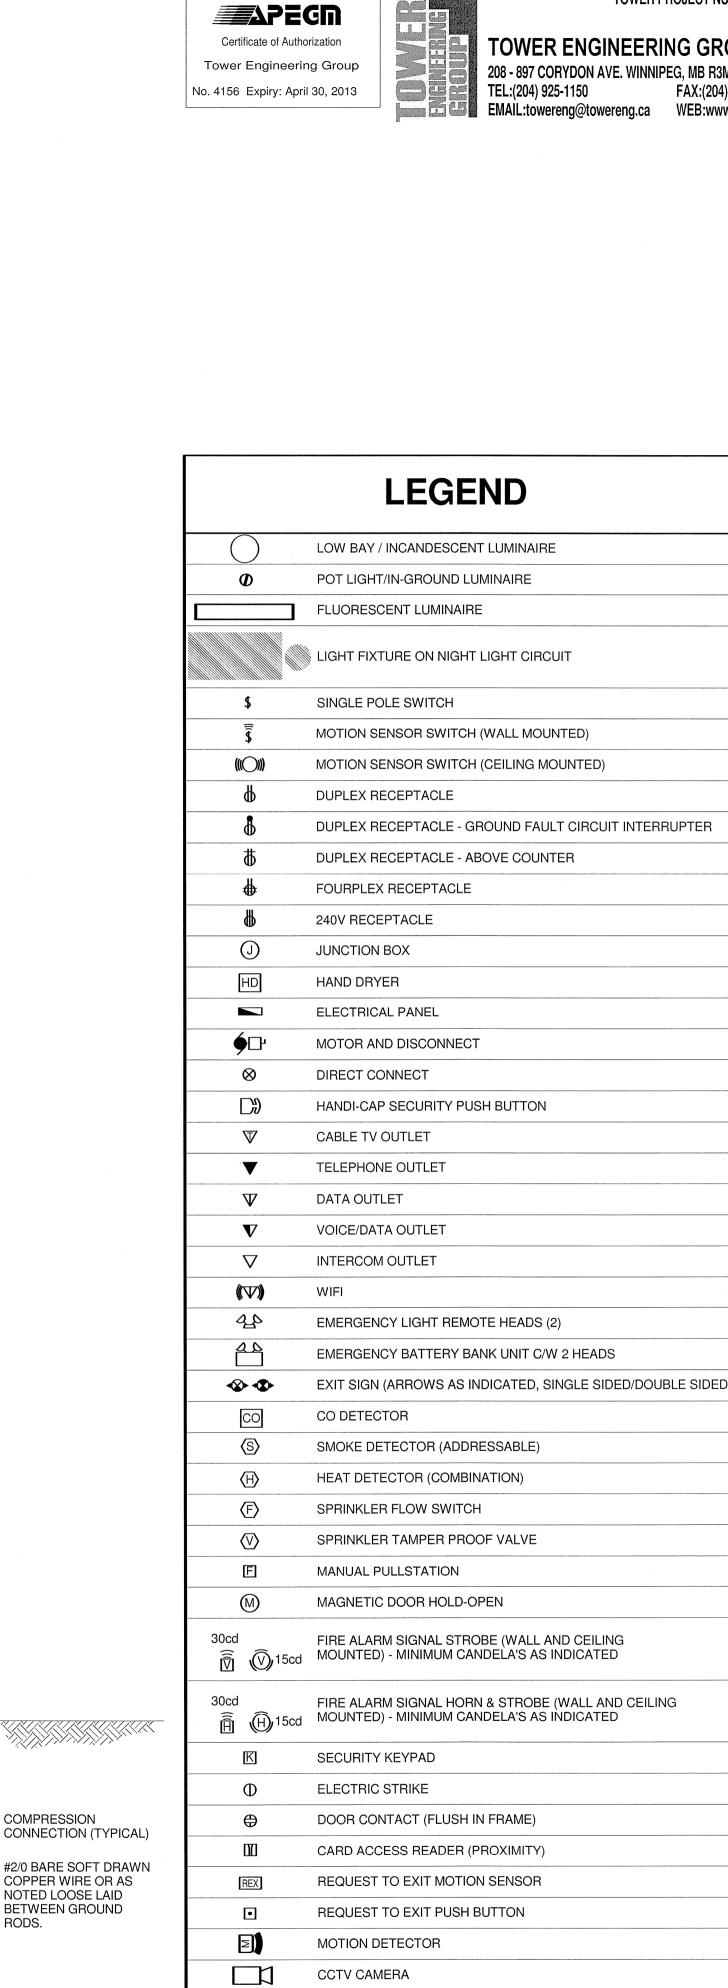

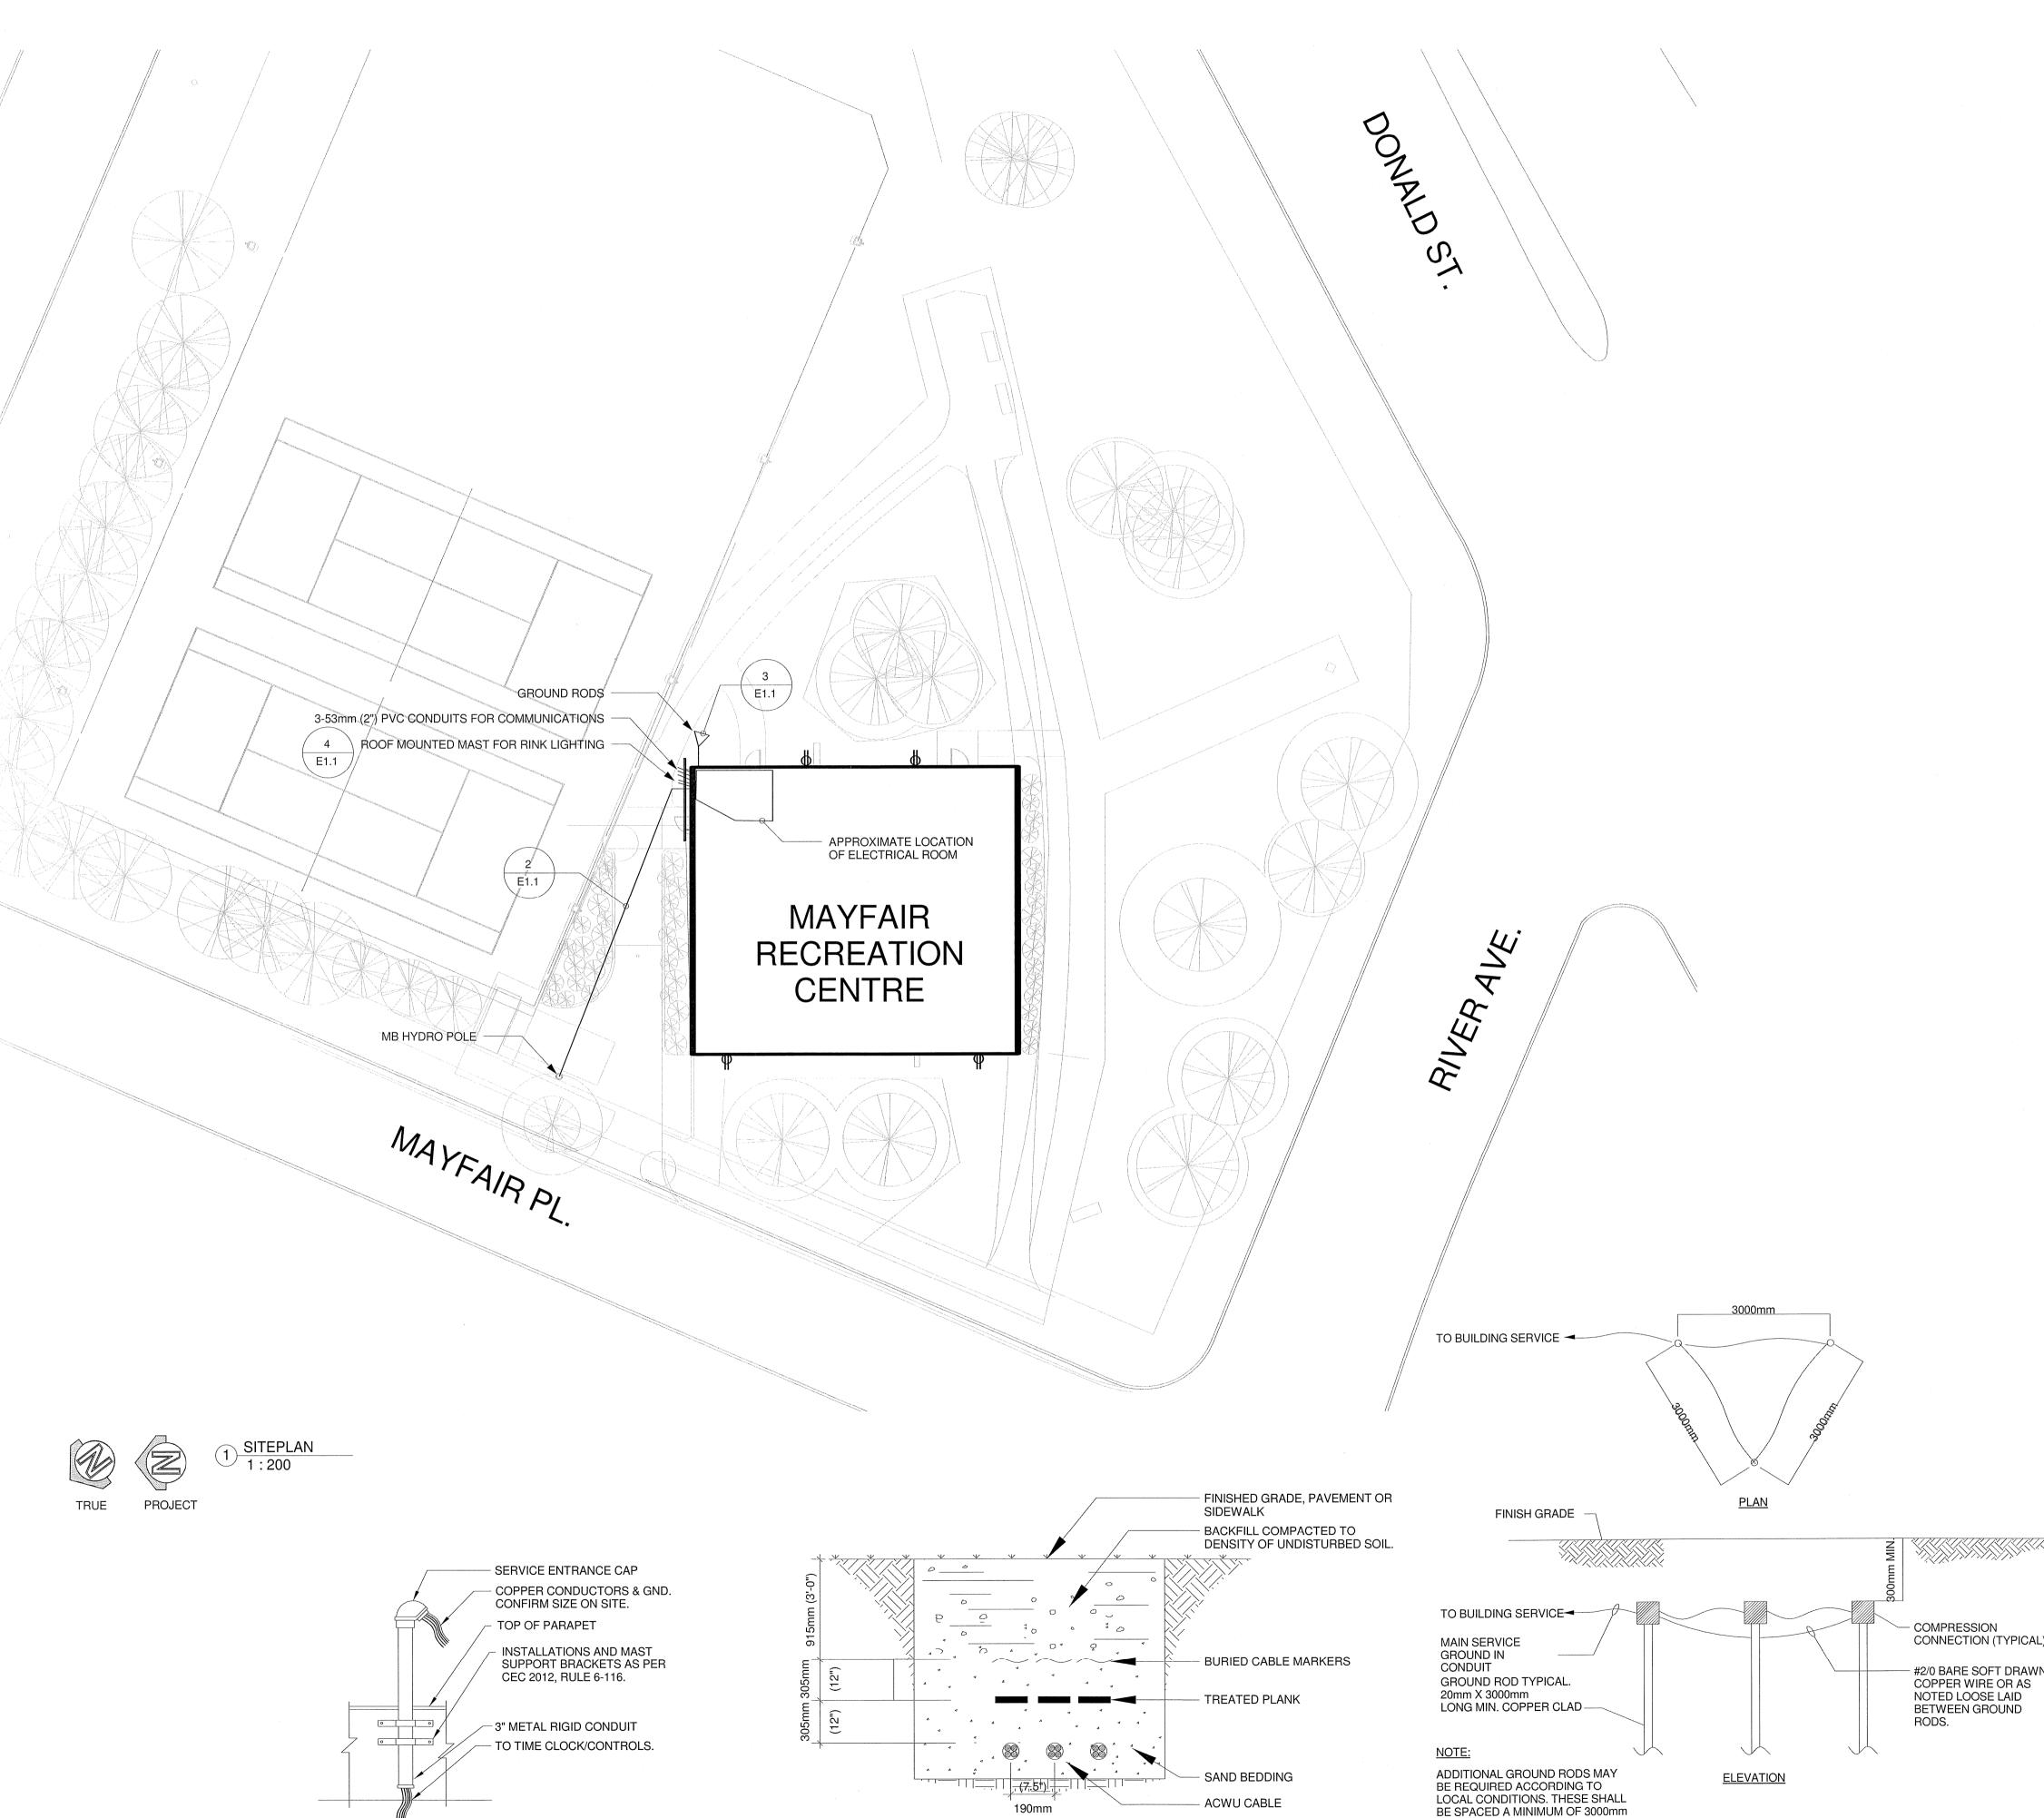

2 U/G FEEDER DETAIL NOT TO SCALE

4 RINK LIGHTS MAST NOT TO SCALE

FROM REMAINING RODS.

3 GROUND RODS DETAIL NOT TO SCALE