



1 ERV CONTROL SCHEMATIC
SCALE: NTS

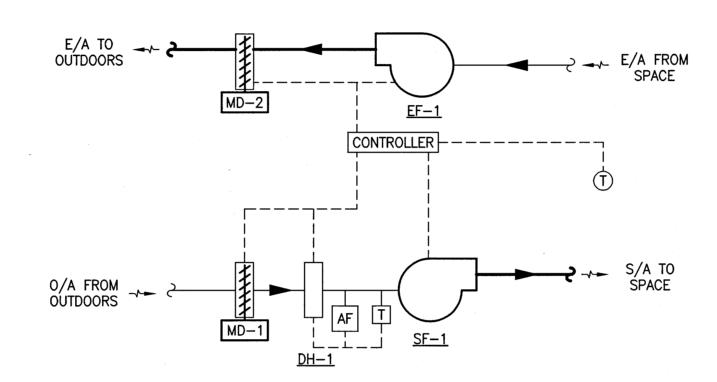

2 RECEIVING/SORTING VENTILATION CONTROL SCHEMATIC SCALE: NTS

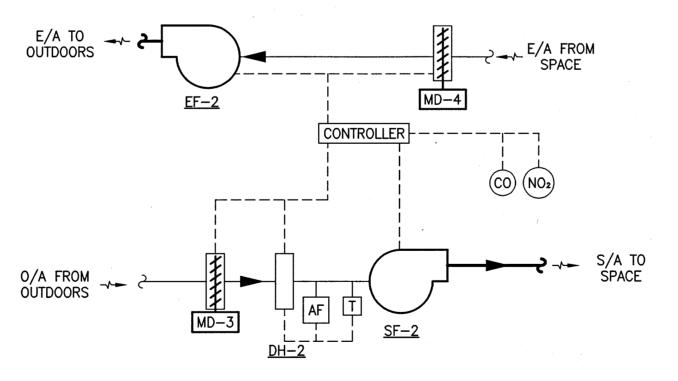

GARAGE VENTILATION CONTROL SCHEMATIC SCALE: NTS

ZAPEGIN Certificate of Authorization

LOCATION APPROVE UNDERGROUND STRUCTURE SUPV. U/G STRUCTURES DATE COMMITTEE LOCATION OF UNDERGROUND STRUCTURES AS SHOWN ARE BASED ON THE BEST INFORMATIC AVAILABLE BUT NO GUARANTEE IS GIVEN THAT ALL EXISTING UTILITIES ARE SHOWN OR THAT THE GIVEN LOCATIONS ARE EXACT. CONFIRMATION OF EXISTENCE AND EXACT LOCATION OF ALL SERVICES MUST BE OBTAINED FROM THE INDIVIDUAL UTILITIES BEFORE PROCEEDING WITH CONSTRUCTION.

ED RES	B.M. ELEV.				KGS GROUP CONSULTING		
					DESIGNED BY	MAP	CHECKED BY
AS RMATION OR					DRAWN BY	EAG	APPROVED BY
	0	ISSUED FOR TENDER	17/03/14	ø	HOR. SCALE: VERTICAL:	AS NOTED AS NOTED	RELEASED FOR CONSTRUCTION:
	NO.	REVISIONS	DATE	BY	DATE	16/08/17	DATE

ENGINEER'S SEAL

Winnipeg PROJECT TITLE

THE CITY OF WINNIPEG WATER AND WASTE DEPARTMENT

LEGEND:

NEW EQUIPMENT/PIPING

ERV-# ENERGY RECOVERY VENTILATOR

--- CONTROL WIRING

O/A OUTDOOR AIR

SF-# SUPPLY FAN

EF-# EXHAUST FAN

DH-# DUCT HEATER

THERMOSTAT

MD-# MOTORZIED DAMPER

T TEMPERATURE SENSOR

AIR FLOW SENSOR

CO CARBON MONOXIDE SENSOR

(NO₂) NITROGEN DIOXIDE SENSOR

SUPPLY AIR

EXHAUST AIR

4R WINNIPEG DEPOT EAST WINNIPEG COMMUNITY

25 COMPUTER FILE NAME RESOURCE RECOVERY CENTRE 16-0107-010 HHW BUILDING CITY DRAWING NUMBER M04 CONTROLS SCHEMATICS

SCALE VERIFIED BY: N/A

KGS Group No. 245

CONSULTANT DRAWING NO. 16-0107-010