




DATE: 2022-11


- 1. ALL EXCAVATED MATERIAL WITHIN 107.0 OF THE ASRL MUST BE REMOVED FROM SITE (NO STOCKPILING).
- 2. CONSTRUCT TEMPORARY CLAY COFFERDAM AT RIVER AS REQUIRED (SEE DWG 1-03030-C0075-001)
- 3. PERMITS AS REQUIRED FOR CONSTRUCTION OF TEMPORARY ACCESS ARE THE RESPONSIBILITY OF THE CONTRACTOR.
- 4. ALL MATERIALS, INCLUDING TEMPORARY MATERIAL PLACED TO CONSTRUCT EQUIPMENT PADS AND ACCESS RAMPS, MUST BE REMOVED FROM SITE FOLLOWING COMPLETION OF WORKS.
- 5. CONTRACTOR TO REMOVE EXISTING DEBRIS GRATE AND INSTALL NEW DEBRIS GRATE.
- 6. REFERENCE APPENDIX A FOR EXISTING OUTFALL CHAMBER AND LIFT STATION RECORD DRAWINGS.
- 7. CONTRACTOR TO RESTORE ALL ROAD, CURBS, PATHWAYS, AND LANDSCAPING FEATURES TO PRE-CONSTRUCTION CONDITION.

SUBSTRATE TYPES BELOW ICE SCOUR AFFECTED BY THE PROJECT		
EXISTING SUBSTRATE	PERMANENT AREA (m²)	TEMPORARY AREA (m²)
COBBLE/BOULDER	0.0	1.0
CLAY WITH EMBEDDED COBBLE/BOULDER	0.0	22.2
CLAY/SILT (SOFT)	0.0	5.0
RIPRAP		144.5
TOTAL AREA AFFECTED	0.0	172.7



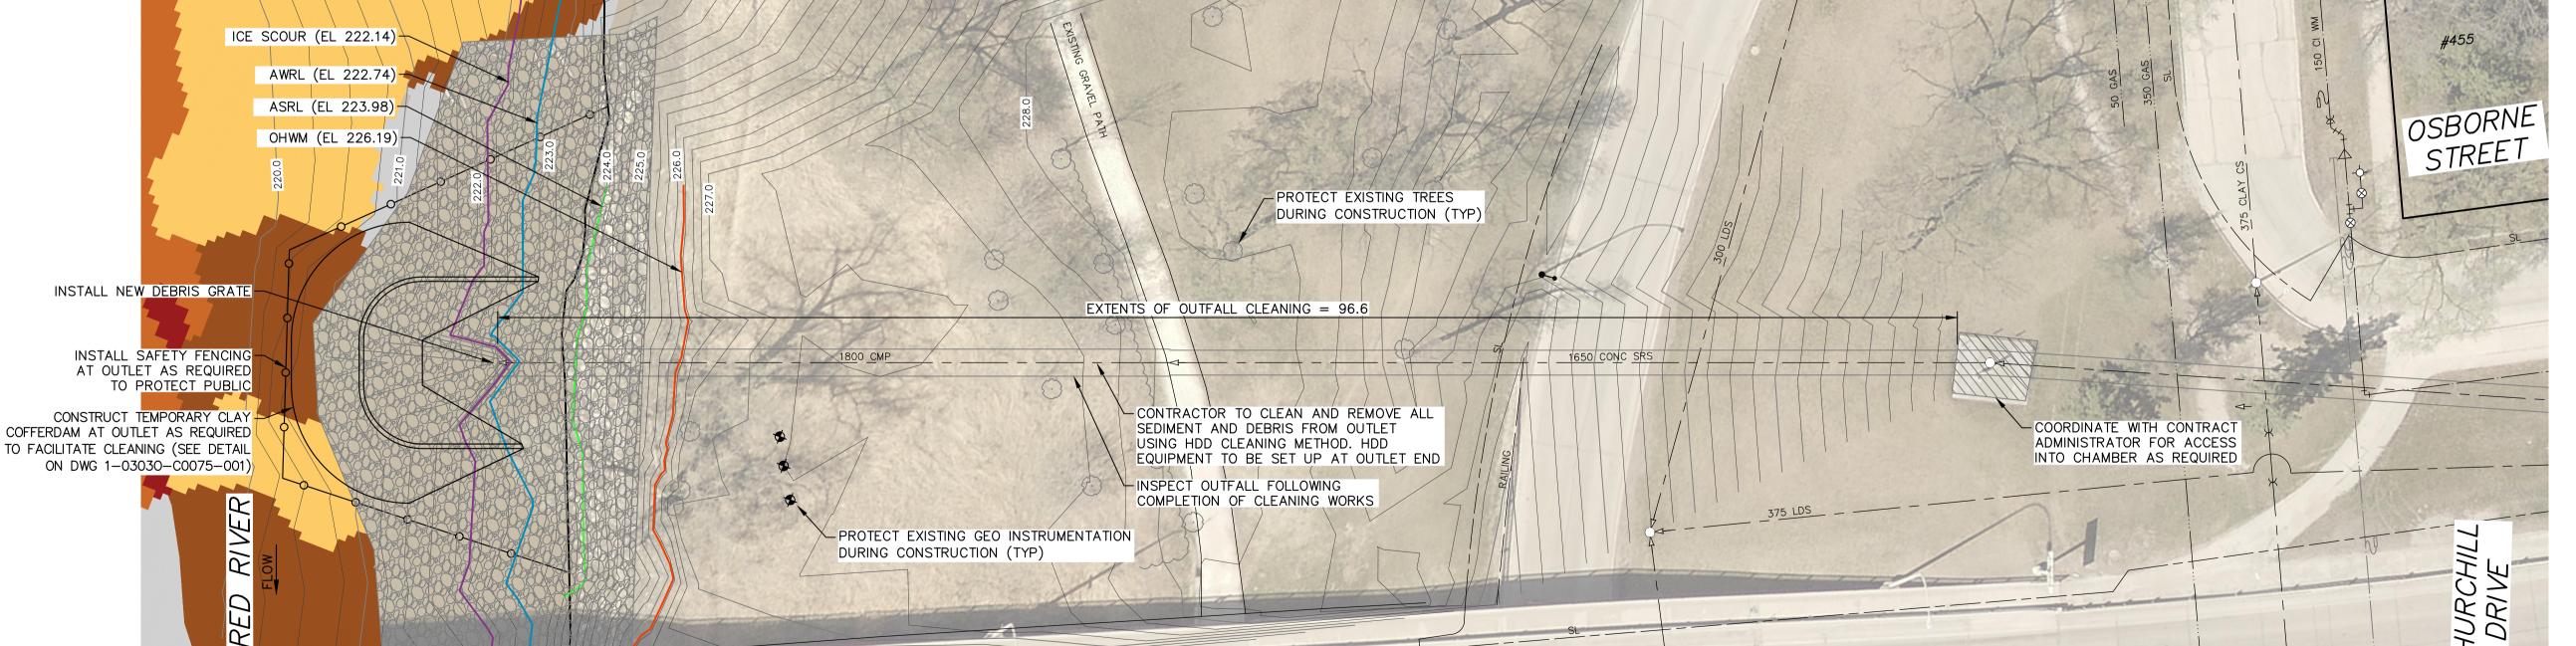

PLAN SCALE 1:250

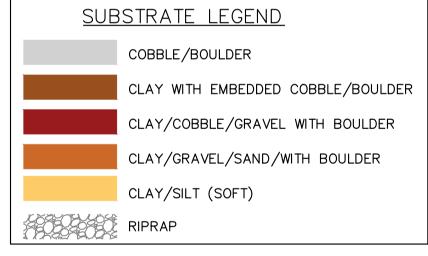

ENGINEERS
GEOSCIENTISTS MANITOBA Certificate of Authorization KGS Group No. 245

THE CITY OF WINNIPEG

WATER AND WASTE DEPARTMENT

ENGINEERING DIVISION

FOR INDEX PAGE SEE DWG 1-03030-D0013-001

METRIC
WHOLE NUMBERS INDICATE MILLIMETRES DECIMALIZED NUMBERS INDICATE METRES 15.0

## WARNING

IF POWER EQUIPMENT OR EXPLOSIVES ARE TO BE USED FOR EXCAVATION ON THIS PROJECT THE CONTRACTOR MUST:

1) NOTIFY THE GAS COMPANY OF THE PROPOSED LOCATION OF EXCAVATION. 2) TAKE PRECAUTION TO AVOID DAMAGE TO GAS COMPANY INSTALLATIONS.

SEE PROVINCIAL REGULATION 210/72 FOR DETAILS

LOCATION APPROVED UNDERGROUND STRUCTURES

SUPV. U/G STRUCTURES COMMITTEE NOTE: LOCATION OF UNDERGROUND STRUCTURES AS SHOWN ARE BASED ON THE BEST INFORMATION AVAILABLE BUT NO GUARANTEE IS GIVEN THAT ALL EXISTING UTILITIES ARE SHOWN OR THAT THE GIVEN LOCATIONS ARE EXACT. CONFIRMATION OF EXISTENCE AND EXACT LOCATION OF ALL SERVICES MUST BE OBTAINED FROM THE INDIVIDUAL UTILITIES BEFORE PROCEEDING WITH CONSTRUCTION.

## ELEV.

ISSUED FOR TENDER

KGS CHECKED BY DESIGNED NGV DRAWN APPROVED SCALE: RELEASED FOR CONSTRUCTION HORIZONTAL 1:250

1:50

2022 12 02

2022 12 02

VERTICAL

DATE

ENGINEER'S SEAL

CONSULTANT DRAWING NUMBER

1-03030-C0072-001

BID OPPORTUNITY: 910-2022

2022 OUTFALL PROGRAM

CHURCHILL DR & OSBORNE ST OUTFALL PLAN AND PROFILE S-MA70006325

I-03030-C0072-001

CITY DRAWING NUMBER

SHEET **8** OF **12** 

FILE PATH: P:\Projects\2022\22-0107-013\Dwg\Mun\FILE NAME: 22-0107-013\_CALL.dwg

Winnipeg