

WU IUI-04

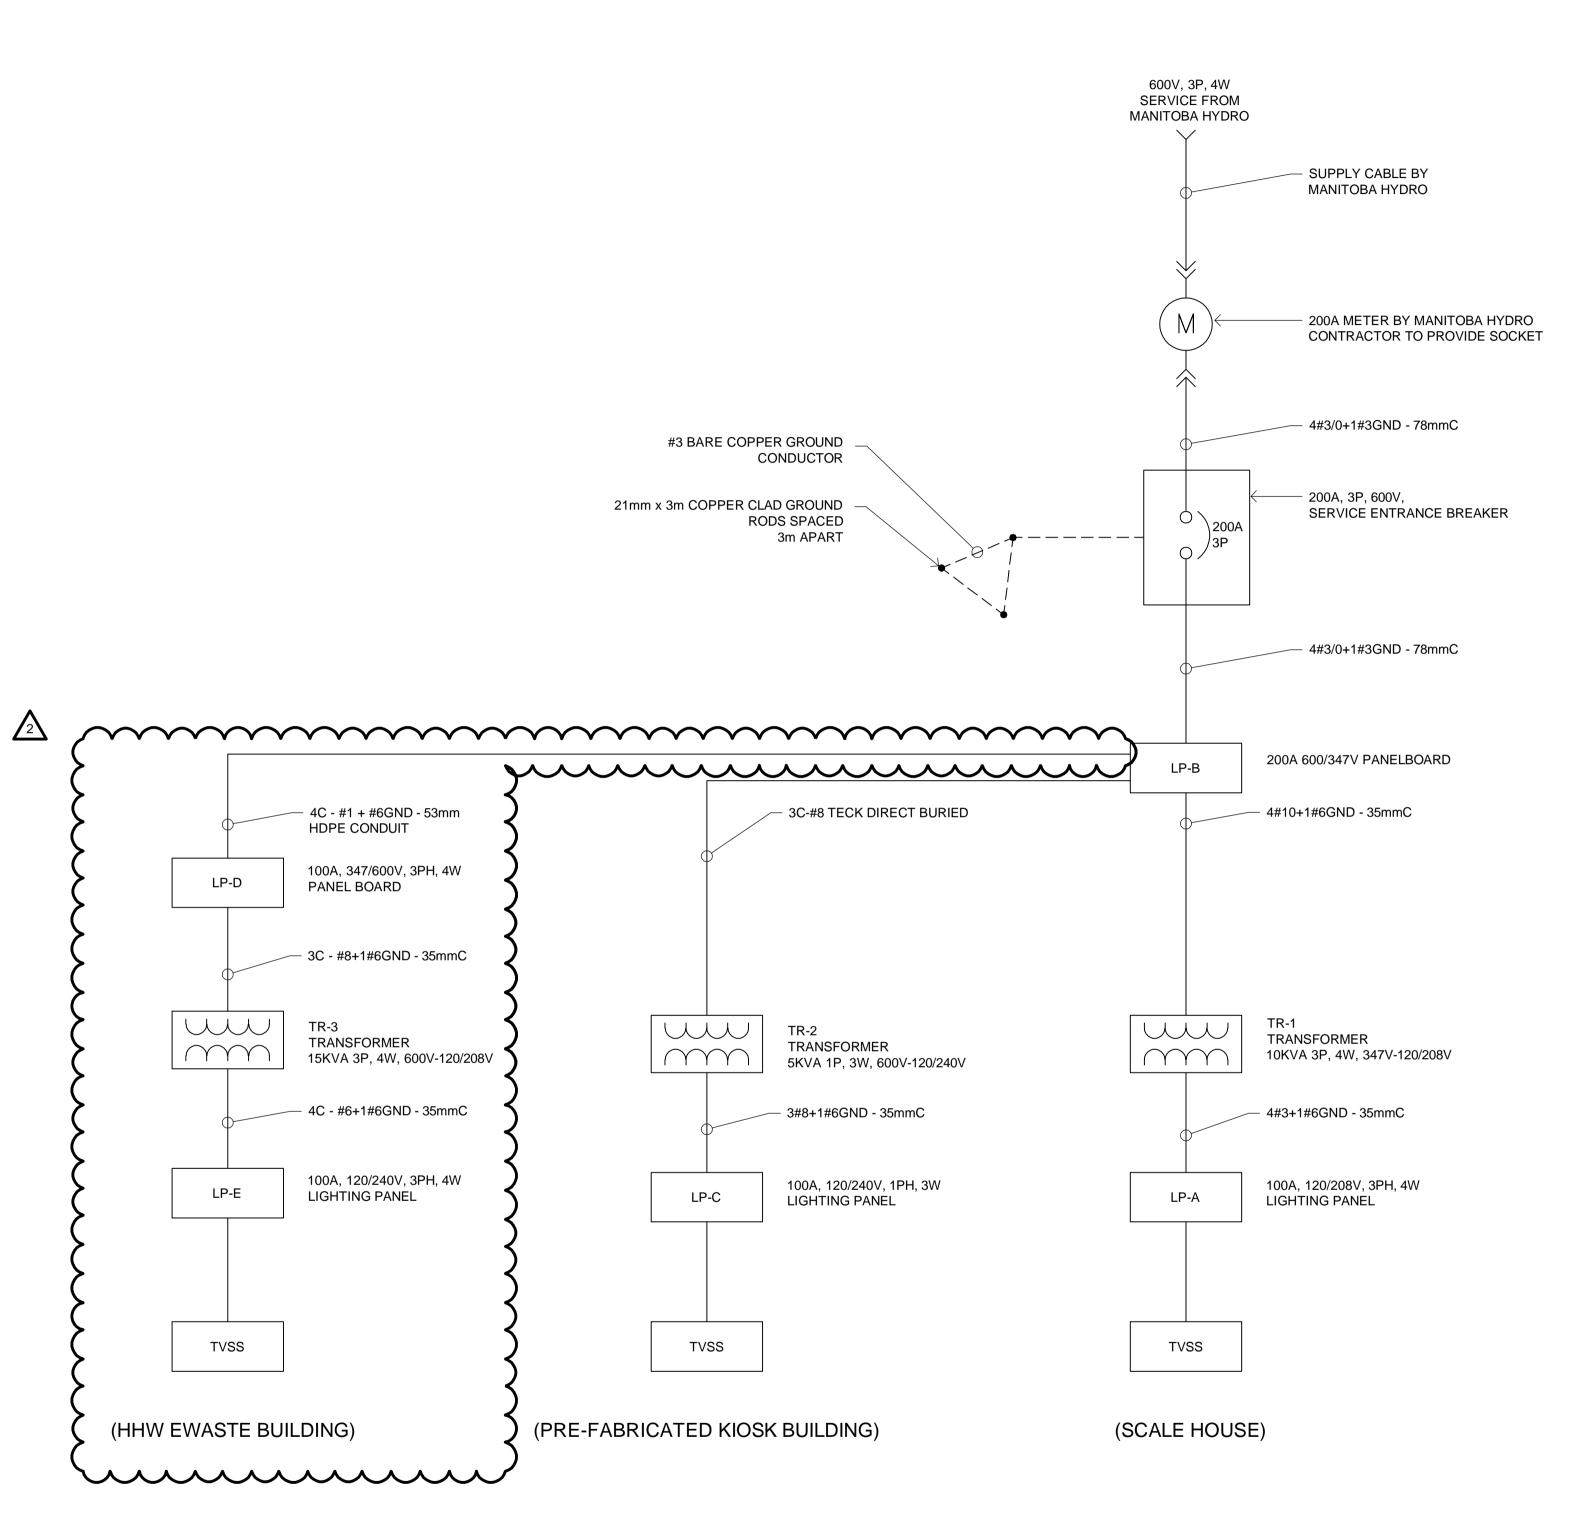

ONE LINE DIAGRAM SCALE: N.T.S.

B.M. ELEV.				DESIGNED BY	JAD	1.	ENGINEER'S SEAL
				DRAWN BY	MS		OF MAL STAMPED BY
				CHECKED BY	BM	DILLON	B.L. MOORE 2014/06/19
				APPROVED BY	ARR	CONSULTING	PROFESSION
2	ISSUED FOR ADDENDUM #1	14/07/08	ARR	HOR. SCALE	AS NOTED	RELEASED FOR CONSTRUCTION	CONSULTANT PROJECT
1 NO.	ISSUED FOR TENDER REVISIONS	14/06/19 DATE	ARR BY	VERTICAL DATE	JULY 2014	DATE	13-8224



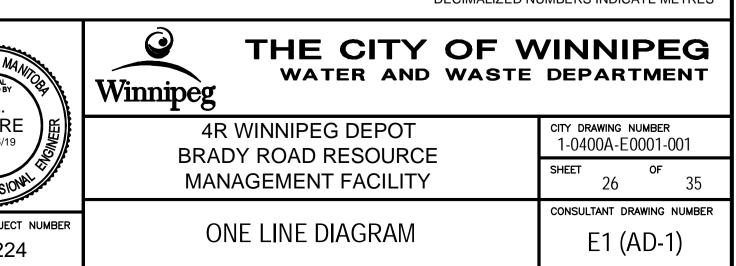

Certificate of Authorization Dillon Consulting Limited (MB) No. 1789 Date: <u>2014/06/19</u>

METRIC

WHOLE NUMBERS INDICATE MILLIMETRES DECIMALIZED NUMBERS INDICATE METRES