

DRAWING NUMBER

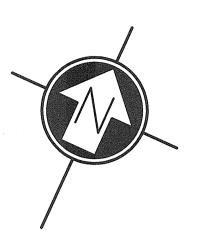

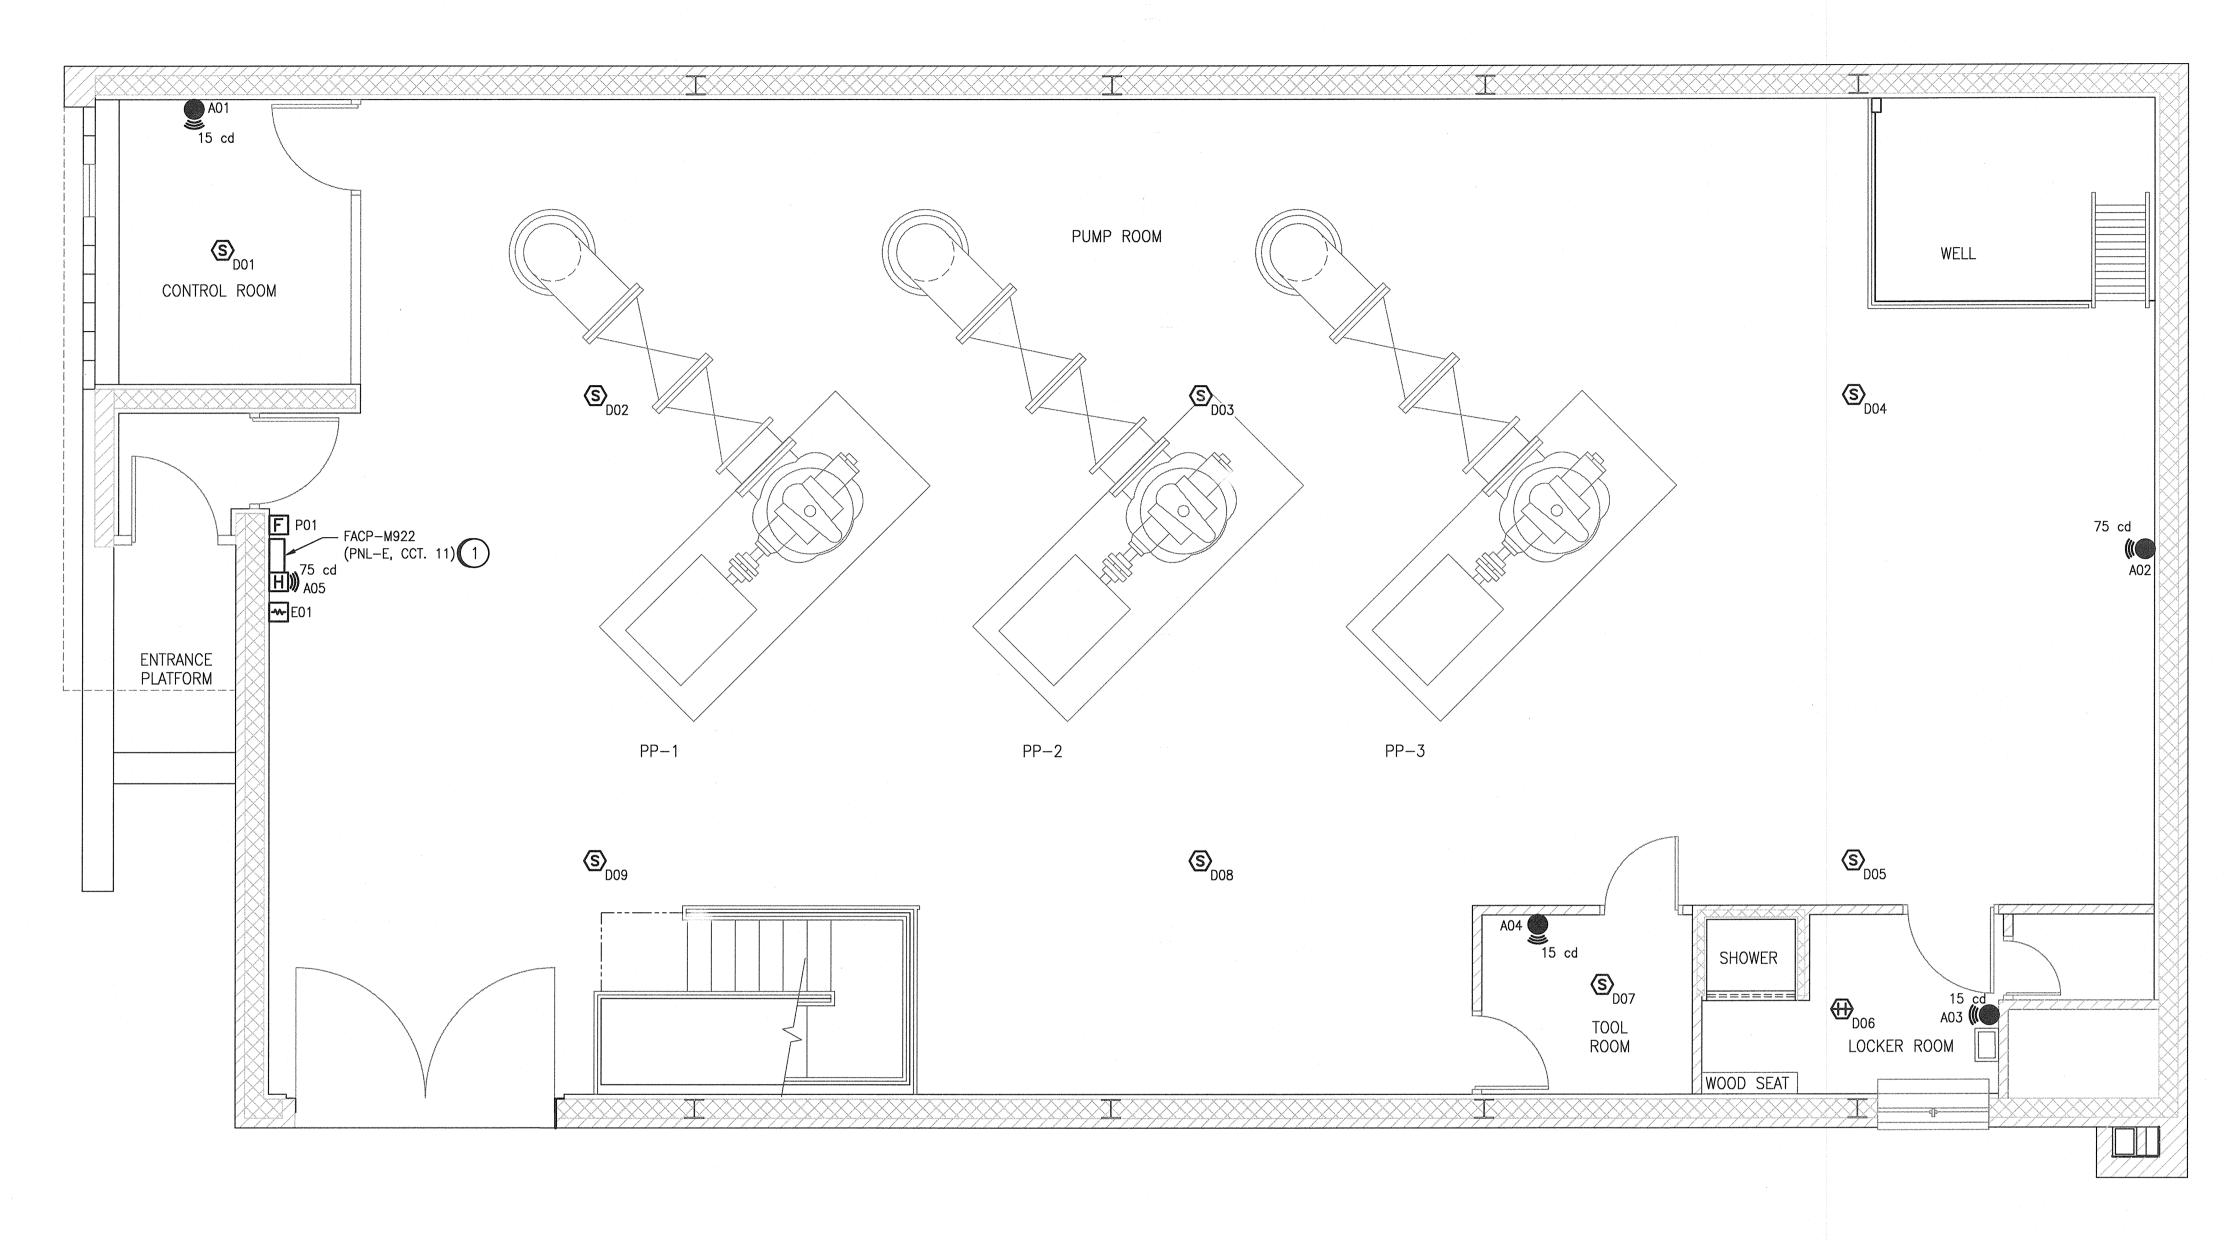

GENERAL NOTES:

- 1. ALL DEVICES SHOWN ARE NEW AND SHALL BE PROVIDED BY THE ELECTRICAL CONTRACTOR.
- ALL WIRING ASSOCIATED WITH FIRE ALARM EQUIPMENT SHALL BE RUN IN CONDUIT AND PROVIDED BY THE ELECTRICAL CONTRACTOR.
- 3. PROVIDE EXPANSION COUPLINGS AND FITTINGS FOR ALL CONDUIT CROSSING EXPANSION JOINTS (IF APPLICABLE).
- 4. UTILIZE A MINIMUM OF #12 AWG WIRE SIZE FOR NOTIFICATION APPLIANCE CIRCUITS (NAC).
- 5. ALL WIRE CONNECTION SHALL BE MADE VIA TERMINAL BLOCKS (MARRETTES NOT ALLOWED).
- 6. ELECTRICAL CONTRACTOR IS RESPONSIBLE TO PROVIDE ANY ADDITIONAL EQUIPMENT IN ORDER TO COMPLETE FIRE ALARM DESIGN.
- 7. REFER TO DRAWING 1-0660M-E0011 FOR FIRE ALARM DEMO WORK.
- 8. UTILIZE A MINIMUM OF #18 AWG FOR DETECTION CIRCUITS.

CONSTRUCTION NOTES:

PROVIDE 15A SINGLE POLE BREAKER ON UPS PANEL PNL-E, CCT. 11 FOR FIRE ALARM POWER FEED. PROVIDE CABLING AND CONDUIT FROM PNL-E TO FIRE ALARM PANEL FACP-M922. REFER TO PANEL SCHEDULE ON 1-0660M-E0009.


-0660M-A0005	LOOP DIAGRAM, FACP-M922.Trouble AND FACP-M922.Alarm
-0660M-E0026	FIRE ALARM, LEGEND AND DETAILS
-0660M-E0025	FIRE ALARM, RISER DIAGRAM, DETECTION & NOTIFICATION CIRCUITS
-0660M-E0024	FIRE ALARM PLAN, BASEMENT
-0660M-E0011	MAIN FLR EQUIPMENT & DEVICE LAYOUT, PUMP ROOM DEMOLITION

REFERENCE DRAWINGS

METRIC WHOLE NUMBERS INDICATE MILLIMETRES DECIMALIZED NUMBERS INDICATE METRES 0.0 0.4 0.8 1.6 1:40

PEGN Certificate of Authorization SNC-Lavalin Inc. No. 4489

			•))	SNC-LAVALIN INC. 148 Nature Park Way				
						SNC·LAVALIN	Winnipeg, MB, Canada R3P 0X7 204-786-8080	
						DESIGNED BY: V. ELIMBAN	CHECKED BY: B. CLEVEN	
						DRAWN BY: C. DUBON	APPROVED BY: D. BECKER	
						SCALE: 1:40	ISSUED FOR CONSTRUCTION BY: A. WEISS	destruction destruction of the second
			·			DATE: 2019/07/15	DATE: 2019/10/18	
	00	ISSUED FOR TENDER AND CONSTRUCTION	2019/10/18	VE	BC	CONSULTANT NO.:		0
L	NO.	REVISIONS	DATE	DESIGN	CHECK			1

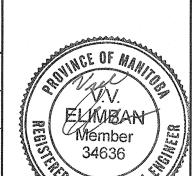

ENGINEER'S SEAL

THE CITY OF WINNIPEG Winnipeg WATER AND WASTE DEPARTMENT

TACHE BOOSTER PUMPING STATION

ELECTRICAL FIRE ALARM PLAN PUMP ROOM

CITY DRAWING NUMBER SHEET REV. SIZE -0660M-E0023

001 | 00 | A1

1-0660M-E0023-001-00.dwg