
**KEY NOTES** 

## GENERAL NOTES

- A. COORDINATE LOCATION AND MOUNTING HEIGHT OF ELECTRICAL DEVICES IN CRAWLSPACE WITH ALL DISCIPLINES AND TRADES PRIOR TO INSTALLATION.
- B. INSTALL CONDUIT WITH NO MORE THAN TWO (2) 90° BENDS BETWEEN PULL BOXES, AND NO MORE THAN 100'-0" (30m) / 30m (100'-0") BETWEEN PULL BOXES. PULL BOXES SHALL BE INSTALLED FOR STRAIGHT THRU PULLS ONLY.
- C. ALL WIRINGS SHALL BE IN CONDUIT.
- D. FIRE ALARM HORN/STROBE SHALL BE MOUNTED ON WALL OF 2ND FLOOR LANDING ONLY. REFER TO RISER DIAGRAM E5.4.
- E. FIRE ALARM DETECTOR SHALL BE MOUNTED ON CEILING OF 3RD FLOOR LANDING ONLY. REFER TO DETAILS.
- F. ELECTRICAL CONTRACTOR SHALL COORDINATE QUANTITIES AND LOCATIONS OF ALL SWITCHES AND VALVES REQUIRING WIRING WITH SPRINKLER CONTRACTOR.

  G. REFER TO FIRE ALARM RISER AND ZONE SCHEDULE FOR INITIATING ZONES AND SIGNAL
- CIRCUITS.

  H. PROVIDE REVERIFICATION OF FIRE ALARM SYSTEM FOR ALL NEW AND MODIFIED
- I. HEAT DETECTORS WITHIN CRAWLSPACE SHALL BE NON-ADDRESSABLE MOISTURE PROOF TYPE.

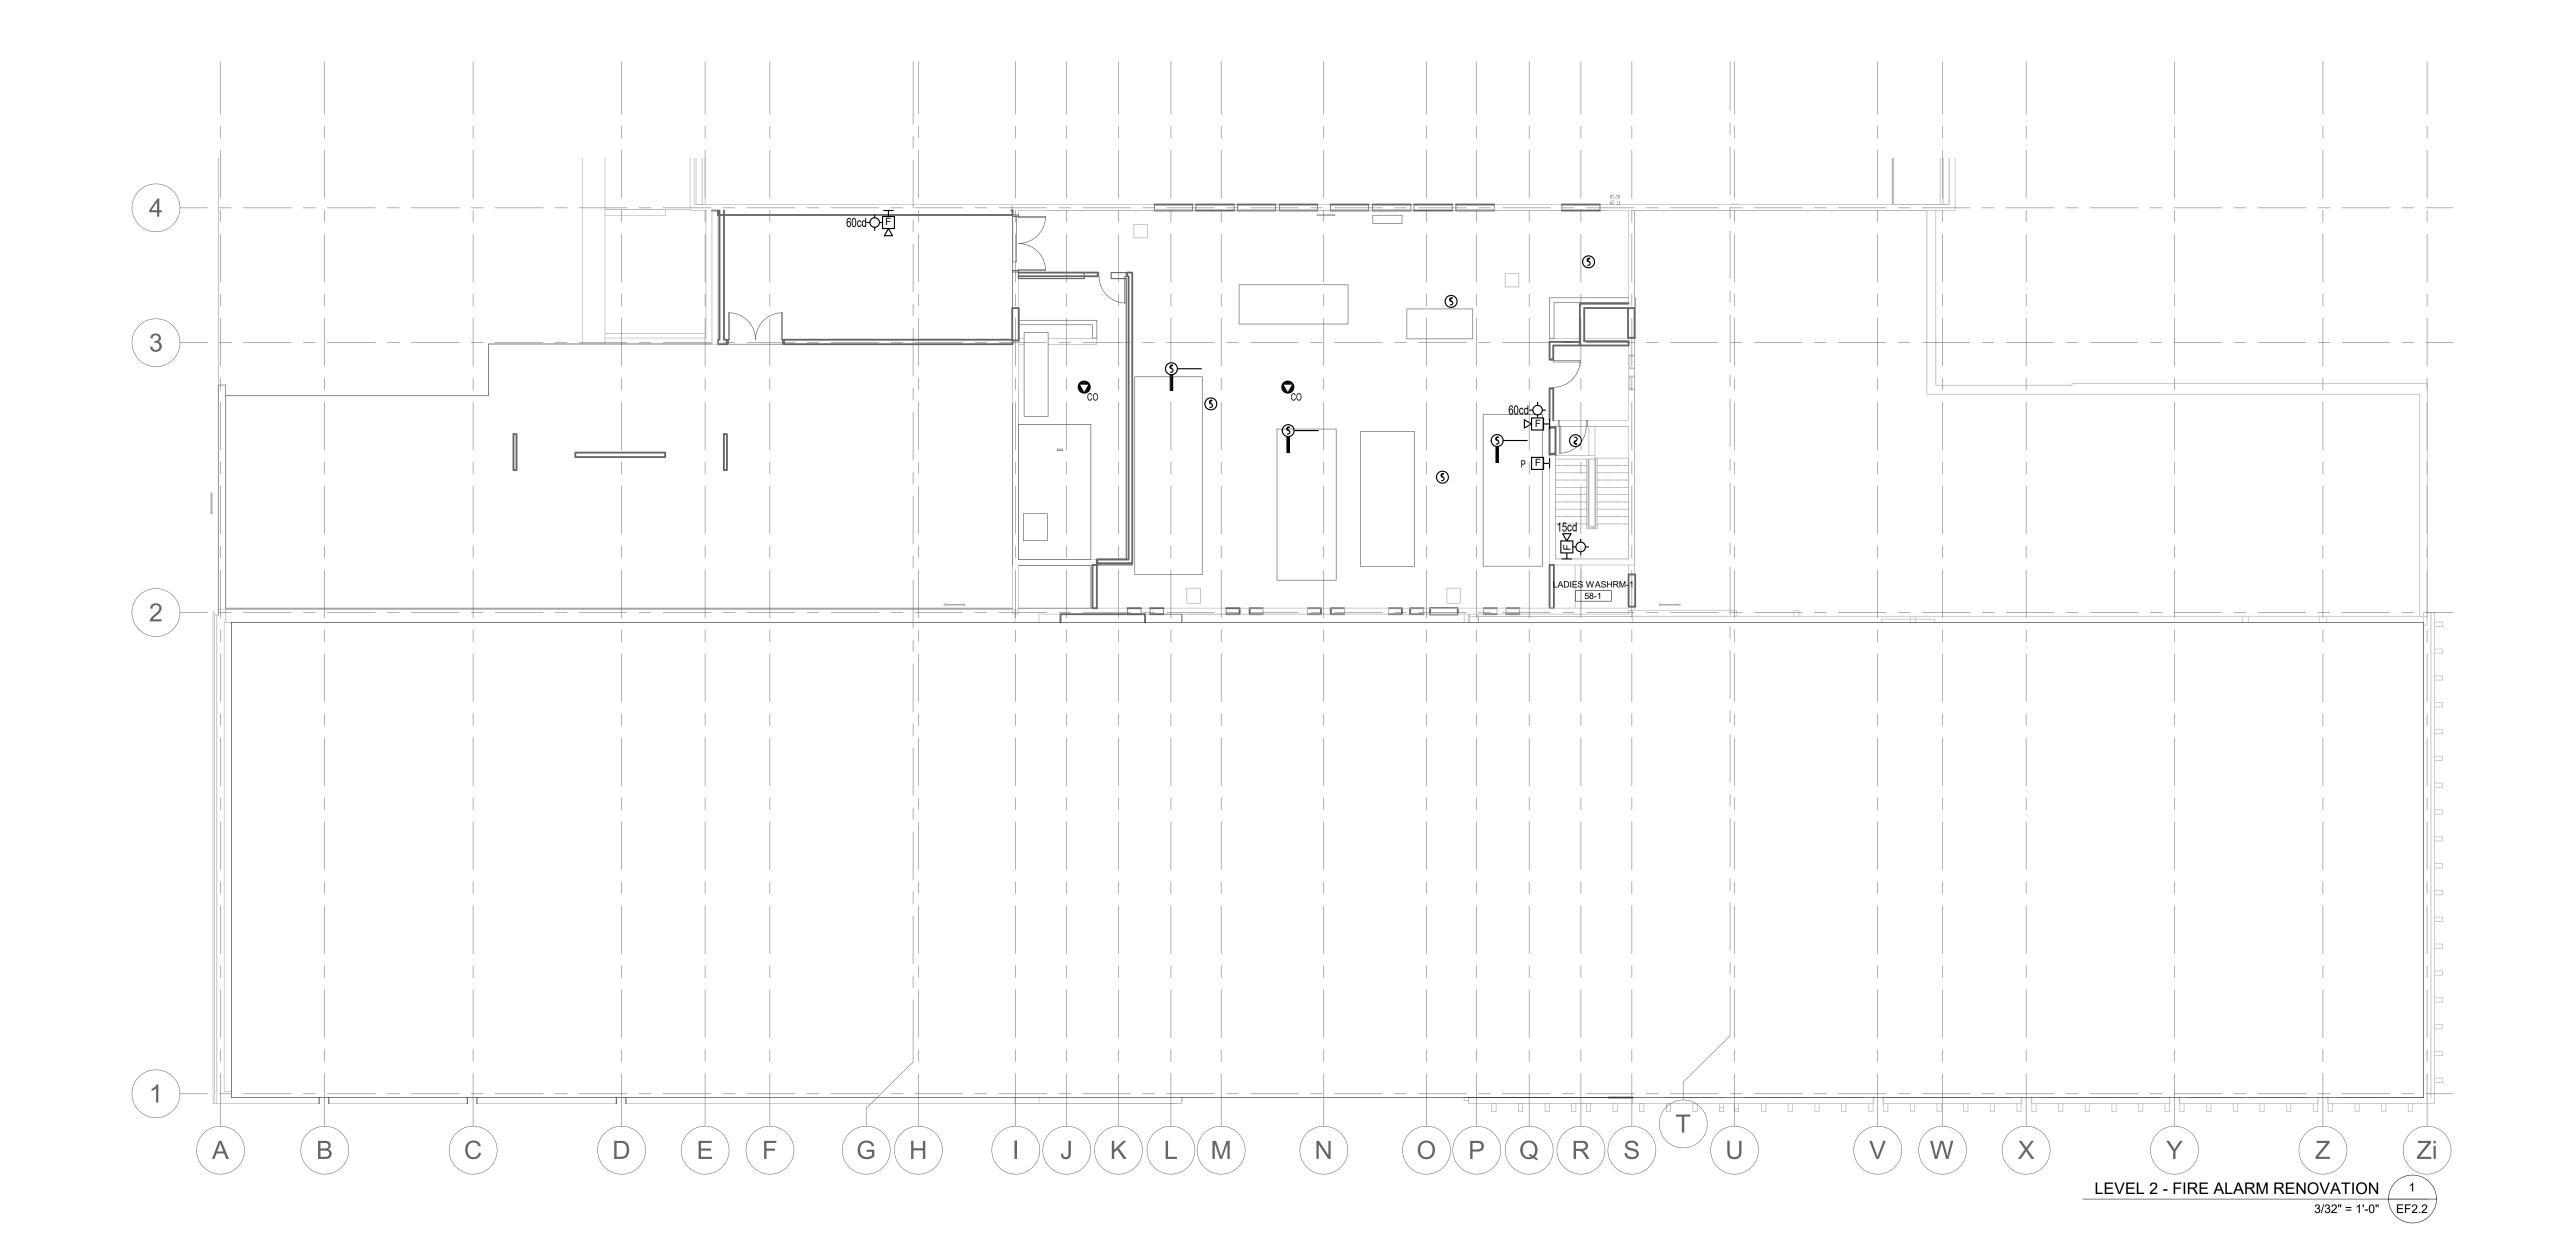



Public City Architecture Inc 11-600 Clifton Street Winnipeg, Manitoba R3G 2X6 204 475 9323 publiccityarchitecture.com

Rev. No. Date Revision Notes


0 19-11-06 Issued for Construction




Certificate of Authorization
Epp Siepman Engineering Inc.

No. 4035

This is a print of a document that has been electronically authenticated with technology authorized by the APEGM. The original is in electronic form.

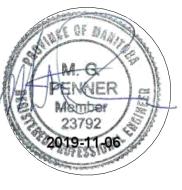

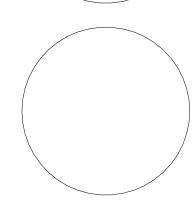

This drawing must not be scaled. The contractors shall verify all dimensions and other data on site prior to commencement of work. Discrepancies, errors, and omissions are to be reported to Public City Architecture Inc. prior to proceeding with the Work.

Drawings and specifications as instruments of service are the property of Public City Architecture Inc.; the copyright in the same being reserved.

Inc.; the copyright in the same being reserved.

No reproduction or revision to these drawings may be made without the permission of Public City Architecture Inc., and when made, must bear their name. All prints to be returned to Public City Architecture Inc. upon request.

Project

ST. JAMES CIVIC CENTRE

Orawing

Sheet:

LEVEL 2 RENOVATION FIRE ALARM PLAN

Drawn By: Review By:

JA MP

Scale: Tender No:
As indicated 1176-2019

Date: 11/06/19

FF2