

0 19-11-06 Issued for Construction




Certificate of Authorization Epp Siepman Engineering Inc.

No. 4035

This is a print of a document that has been electronically authenticated with technology authorized by the APEGM. The original is in electronic form.



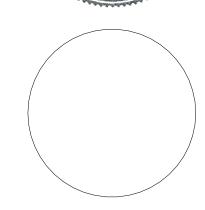

This drawing must not be scaled. The contractors shall verify all dimensions and other data on site prior to commencement of work. Discrepancies, errors, and omissions are to be reported to Public City Architecture Inc. prior to proceeding with the Work. Drawings and specifications as instruments of service are the property of Public City Architecture Inc.; the copyright in the same being reserved.


No reproduction or revision to these drawings may be made without the permission of Public City Architecture Inc., and when made, must bear their name. All prints to be returned to Public City Architecture Inc. upon request.

ST. JAMES CIVIC CENTRE

ARENA NORTH- FIRE PROTECTION PLAN Drawn By:

Review By: GC Tender No: Scale: 3/32" = 1'-0" 1176-2019 11/06/19 Date:

MF2.6

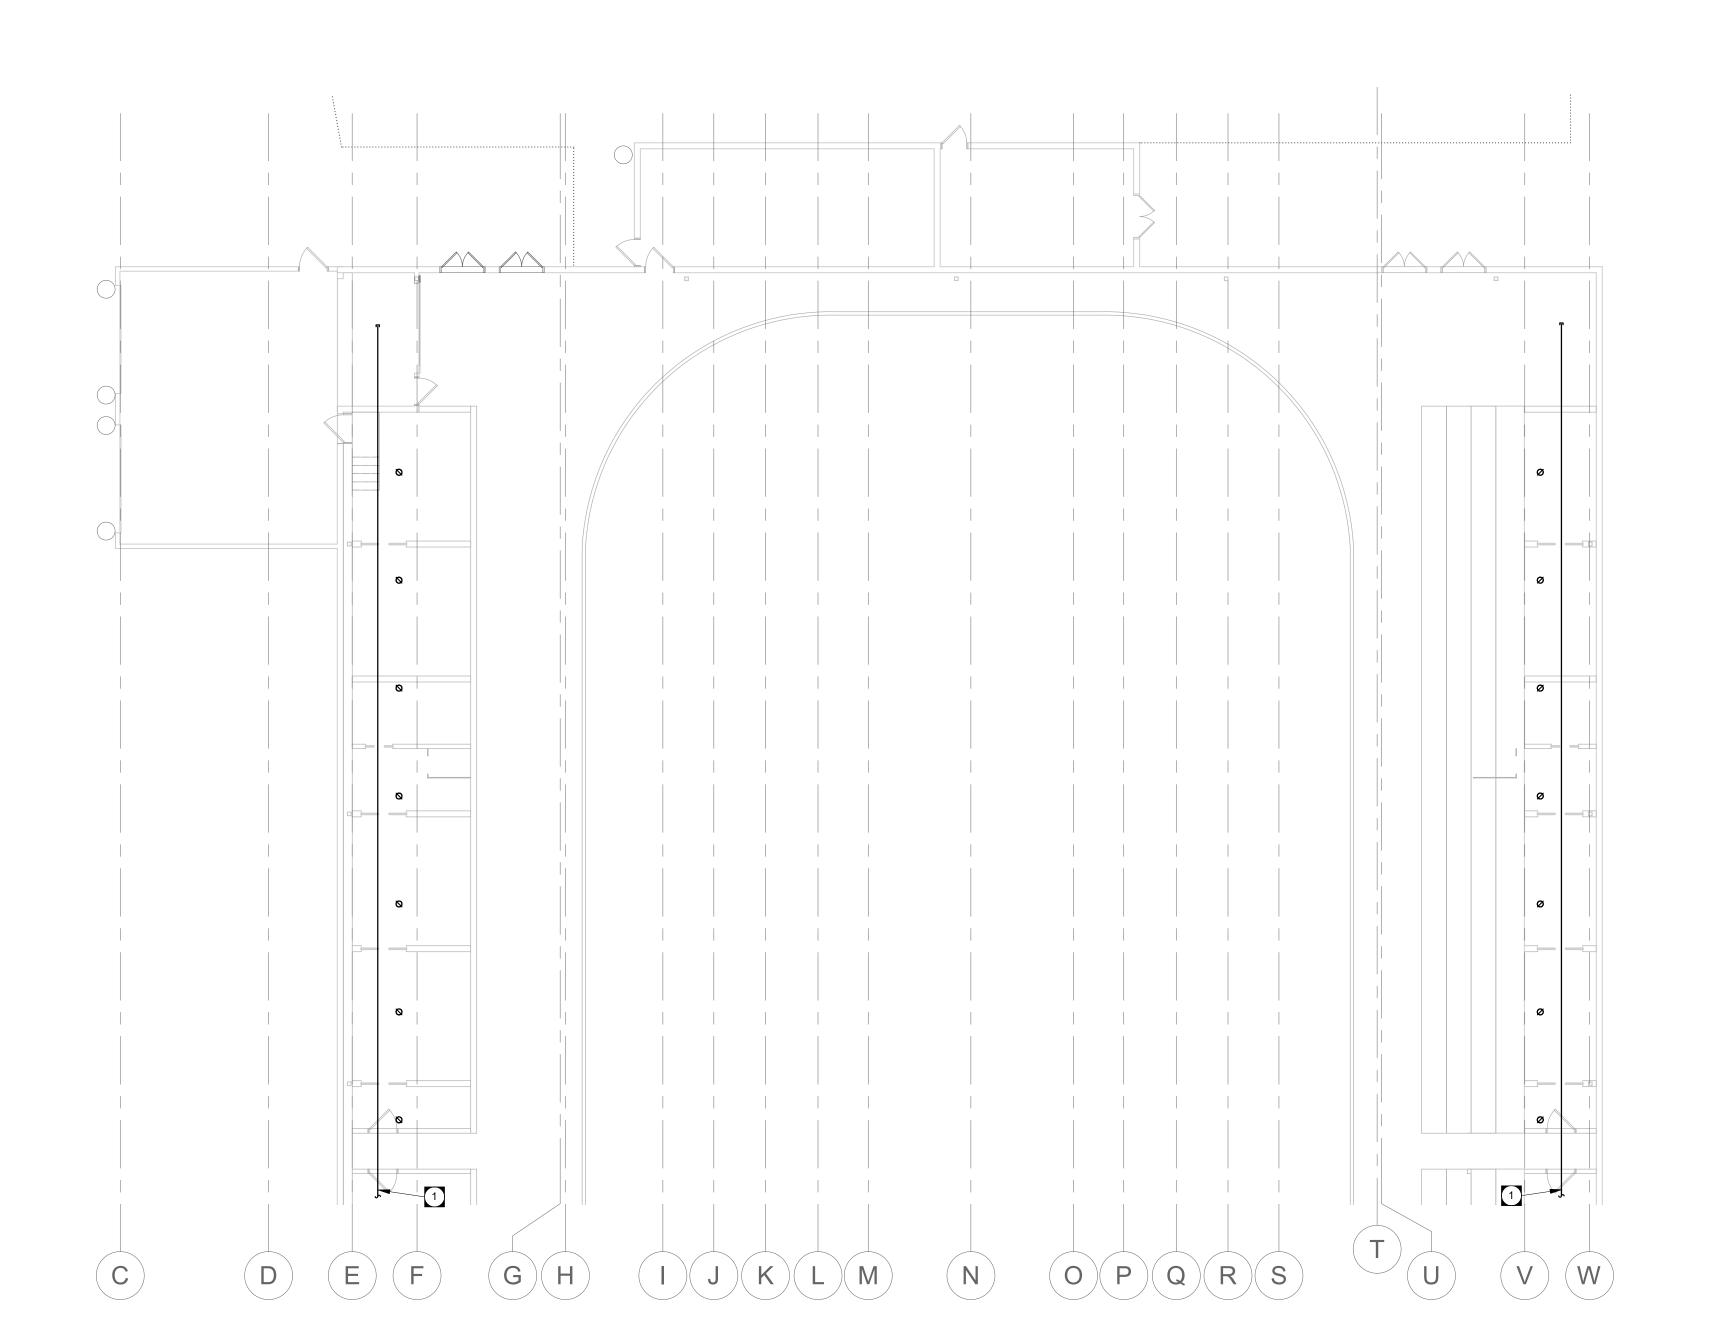

ARENA NORTH LOW LEVEL - FIRE PROTECTION RENOVATION 1 3/32" = 1'-0" MF2.6