




FOUNDATION PLUMBING PLAN SCALE: 1:100

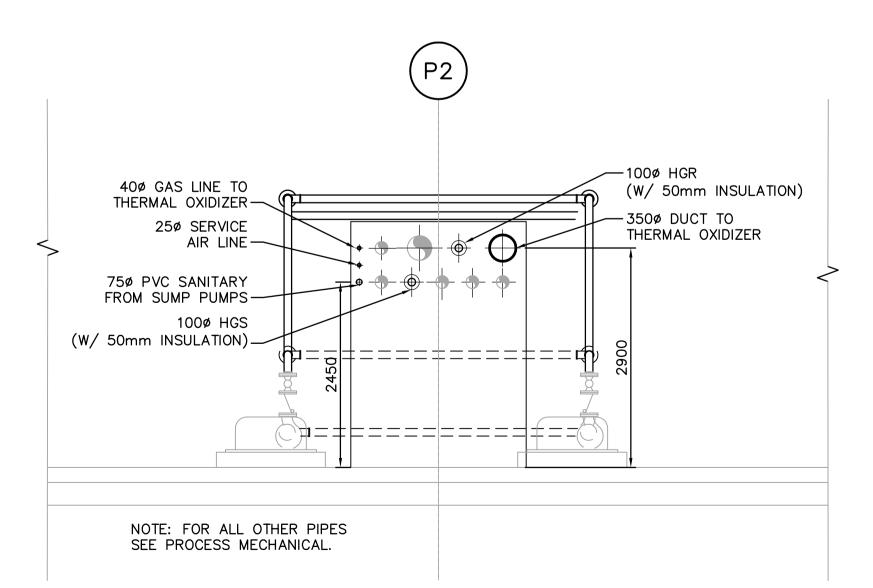

1 SECTION - PIPE & DUCT PENETRATION LOCATION SCALE 1:50

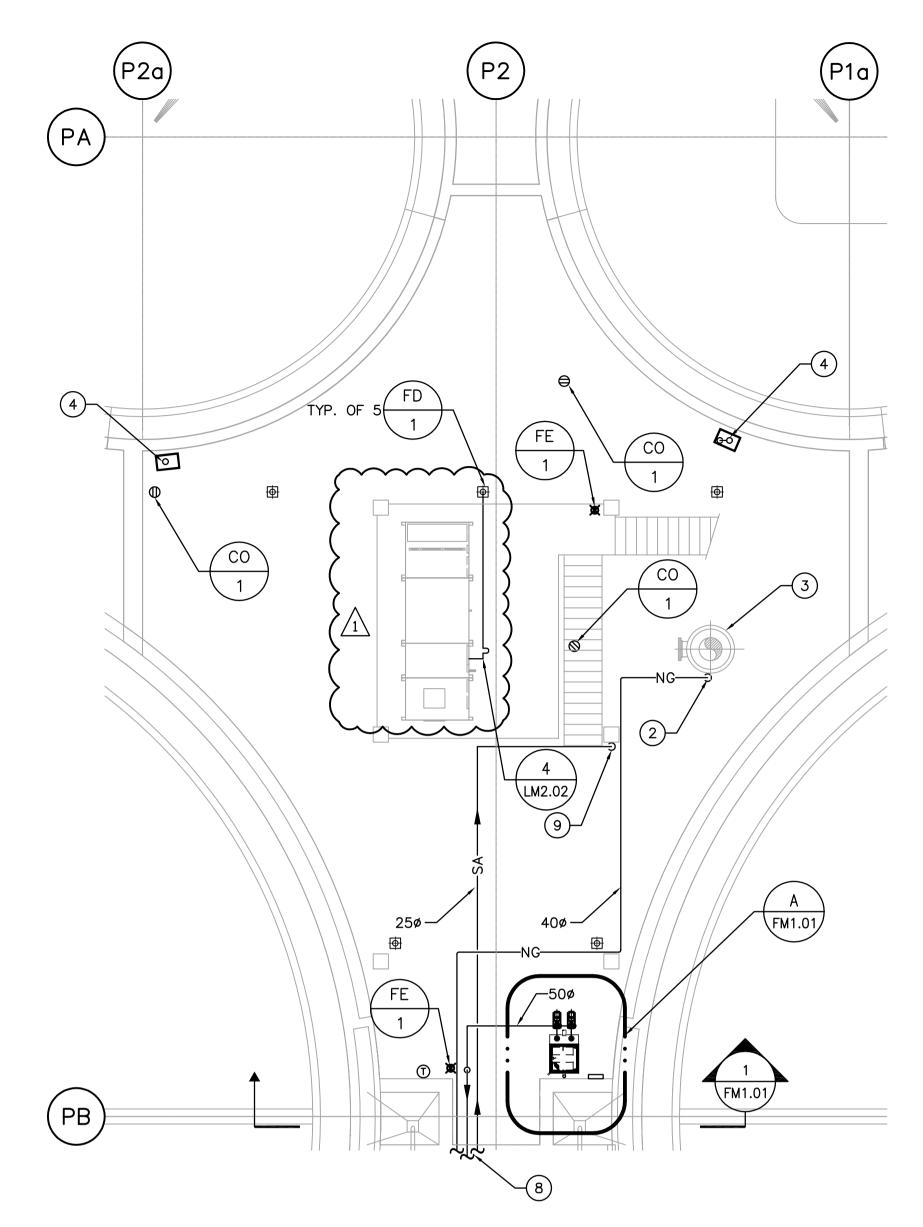

LOWER LEVEL PLUMBING PLAN
SCALE: 1:100

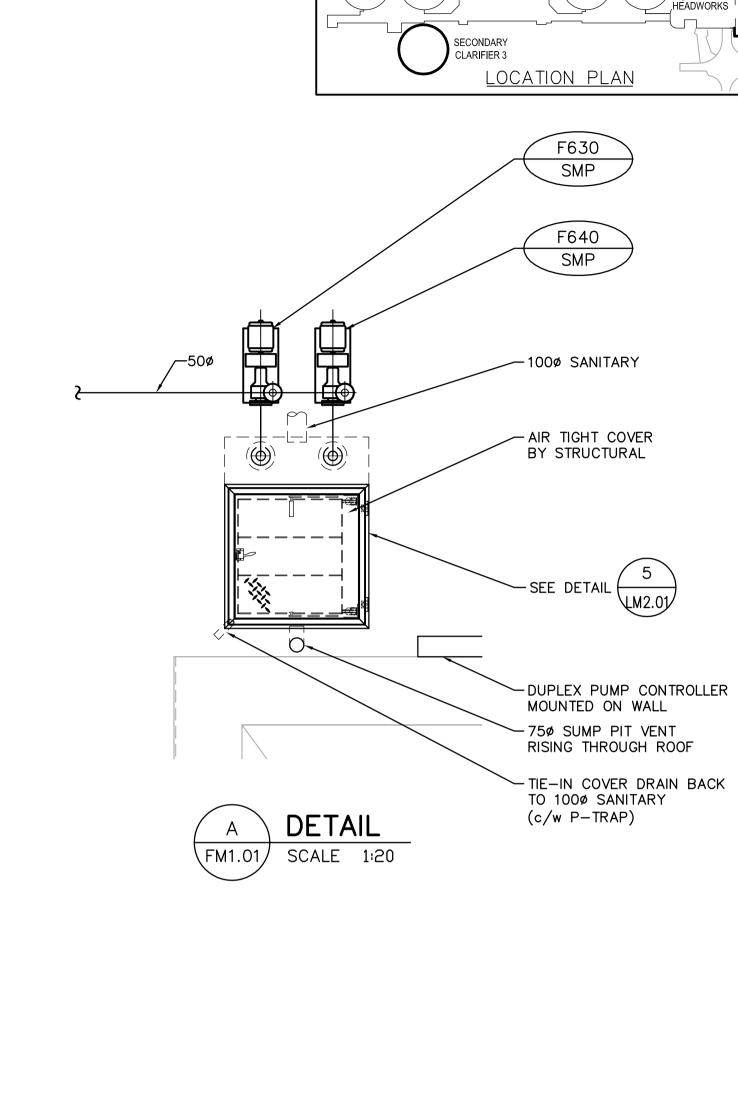

CLARIFIER 2 CLARIFIER 1

BIOREACTORS

BUILDING ADMINISTRATION

PRIMARY SLUDGE

DRAWING NOTES

- 1) 1012Lx762Wx2500 DEEP SUMP PIT.
- 2 LOCATED GAS COCK AND PRESSURE REDUCER NEAR F661-TO.
- 3 PROCESS MECHANICAL THERMAL OXIDIZER.
- 4) 500 SANITARY SERVING DIVISION II SERVICE SINK (SK-1).
- 5 SANITARY LINE EL. INV: 235.676.
- 6 SANITARY LINE EL. INV: 235.757.
- 7 SANITARY LINE EL. INV: 235.506.
- 8 SEE DRAWING PM1.01 FOR CONTINUATION.
- 9 RUN SERVICE AIR LINE DOWN ON MEZZANINE SUPPORT COLUMN. SEE DRAWING LM2.02 FOR SERVICE AIR CONNECTION DETAIL.
- (10) FIRE EXTINGUISHER LOCATED ON MEZZANINE LEVEL.

PLUMBING PLANS & SECTION

GENERAL NOTES

- 1. COORDINATE WITH OTHER TRADES SO AS TO PREVENT CONFLICTS.
- 2. ALL SANITARY PIPE 750 AND SMALLER SHALL BE SLOPED AT 2%.
- 3. ALL SANITARY PIPE 1000 AND LARGER SHALL BE SLOPED AT 1%.

Certificate of Authorization
Earth Tech Canada Inc.
No. 730 Expiry: April 30, 2006

B.M. ELEV.			Earth Tech			ENGINEER'S SEAL		
			A Tyco International Ltd. Company				ORIGINAL SIGNED BY	V
			DESIGNED BY	DC	CHECKED BY	PVL	A. BURACHYNSKY	
			DRAWN BY	DC	APPROVED BY	JEH	2006/04/26	
01 21-2006 ADDENDUM 3	06/05/19	LJW	HOR. SCALE:	AS NOTED	RELEASED FOR CONSTRUCTION BY:			
00 ISSUED FOR TENDER	06/04/26	DC	VERTICAL SCALE: DATE 2005/12/19		J. VEILLEUX DATE 2006/04/26		CONSULTANT DRAWING NO.	
NO. REVISIONS	DATE	BY					FM1.01	ĺ

THE CITY OF WINNIPEG
WATER AND WASTE DEPARTMENT
ENGINEERING DIVISION

WEWPCC

CITY FILE NUMBER

BIOLOGICAL NUTRIENT REMOVAL UPGRADE
CONTRACT 3

MECHANICAL
AREA F - PRIMARY SLUDGE FERMENTERS