1-0102G-A0095

1-0102G-A0026

DRAWING NUMBER


P&ID, WET WELL SUPPLY AND EXHAUST FANS

REFERENCE DRAWINGS

P&ID, G682-AHU

NOTES:

1. THIS DRAWING SUPERCEDES PART OF SEP-837.

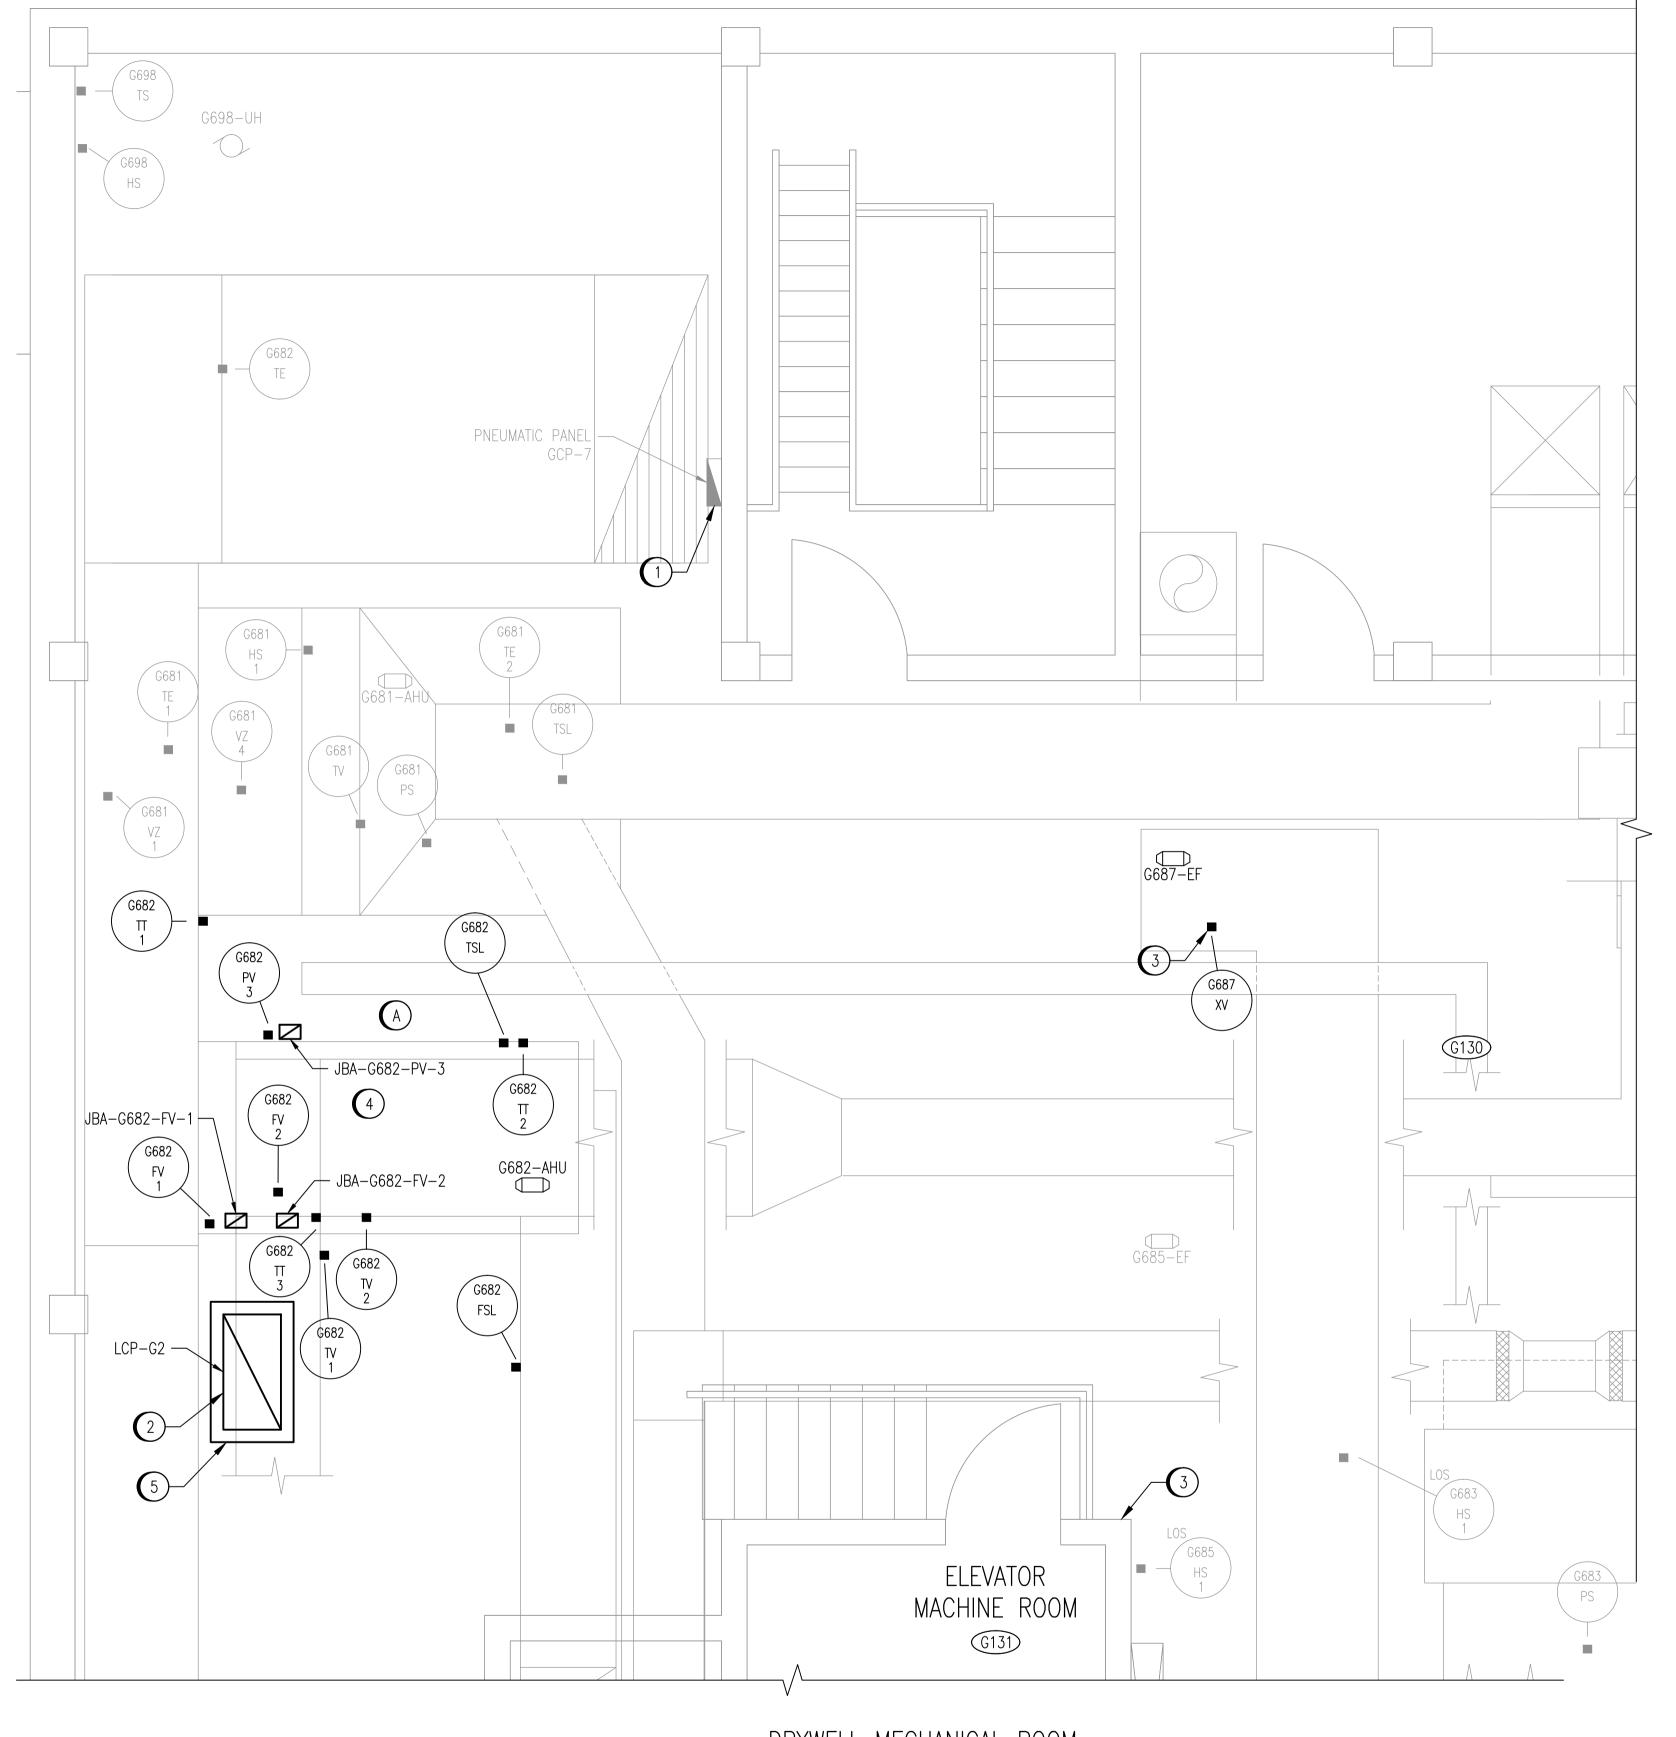

## DRYWELL MECHANICAL ROOM

## 300 0 300 900 1500

Certificate of Authorization	
SNC-Lavalin Inc.	
No. 4489	00

				<b>•))</b>	SNC-LAVALIN INC. 148 Nature Park Way	Engineer's si		
						SNC+LAVALIN  Winnipeg, MB, Canada R3P 0X 204-786-8080		
						DESIGNED BY: T. CHURCH	CHECKED BY: C. REIMER	
						DRAWN BY: MJ. PERSSON	APPROVED BY: C. REIMER	
						SCALE: 1 : 30	RELEASED FOR CONSTRUCTION BY: N. HARRINGTON	
						DATE: 2012/01/26	DATE: 2012/10/19	
00	00	ISSUED FOR TENDER, BID OPP. 545-2012	2012/11/21	TMC	CJR	CONSULTANT NO.:	0110 1000 0001	1
	NO.	REVISIONS	DATE	DESIGN	IGN CHECK	1125//-	577-0116-48DD-0001	

WATER AND WASTE DEPARTMENT SOUTH END WATER POLLUTION CONTROL CENTRE VENTILATION & MISC UPGRADES INSTRUMENT LOCATION PLAN DRYWELL MECHANICAL ROOM - G130

THE CITY OF WINNIPEG

WEST SIDE SHEET REV. SIZE 001 00 A1 CITY DRAWING NUMBER 1-0102G-A0099

1-0102G-A0099-001-00.dwg