KEYNOTES:

RETAIN EXISTING EXHAUST DUCT TO TIE INTO NEW EXHAUST SYSTEM.

REMOVE EXISTING DUCT. RETAIN PENETRATIONS FOR NEW DUCTWORK AND GRILLES.

RETAIN EXISTING DUCT SERVING MEZZANINE OFFICE. MODIFY DUCT TO SUIT NEW DESIGN.

RETAIN WASHROOM AND CHLORINE EXHAUST SYSTEM.

RETAIN EXISTING POOL EXHAUST SYSTEM.

REMOVE EXHAUST FAN F-4 AND ASSOCIATED DUCTWORK TO EXTENT SHOWN.


REMOVE SUPPLY DUCT TO EXTENT SHOWN AND CAP SUPPLY DUCT AT FLOOR LEVEL.

REMOVE EXISTING AIR HANDLER AND ASSOCIATED DUCTWORK, CONTROLS, AND EQUIPMENT.

REMOVE EXISTING WALL A/C UNIT AND DISPOSE OF OFF SITE. PATCH HOLE IN WALL.

RETAIN EXISTING WATER HEATER AND MOP SINK (NOT SHOWN FOR CLARITY).

REMOVE EXISTING ELECTRIC HEATING COIL AND DISPOSE OF OFF SITE. REMOVE ALL RELATED POWER AND

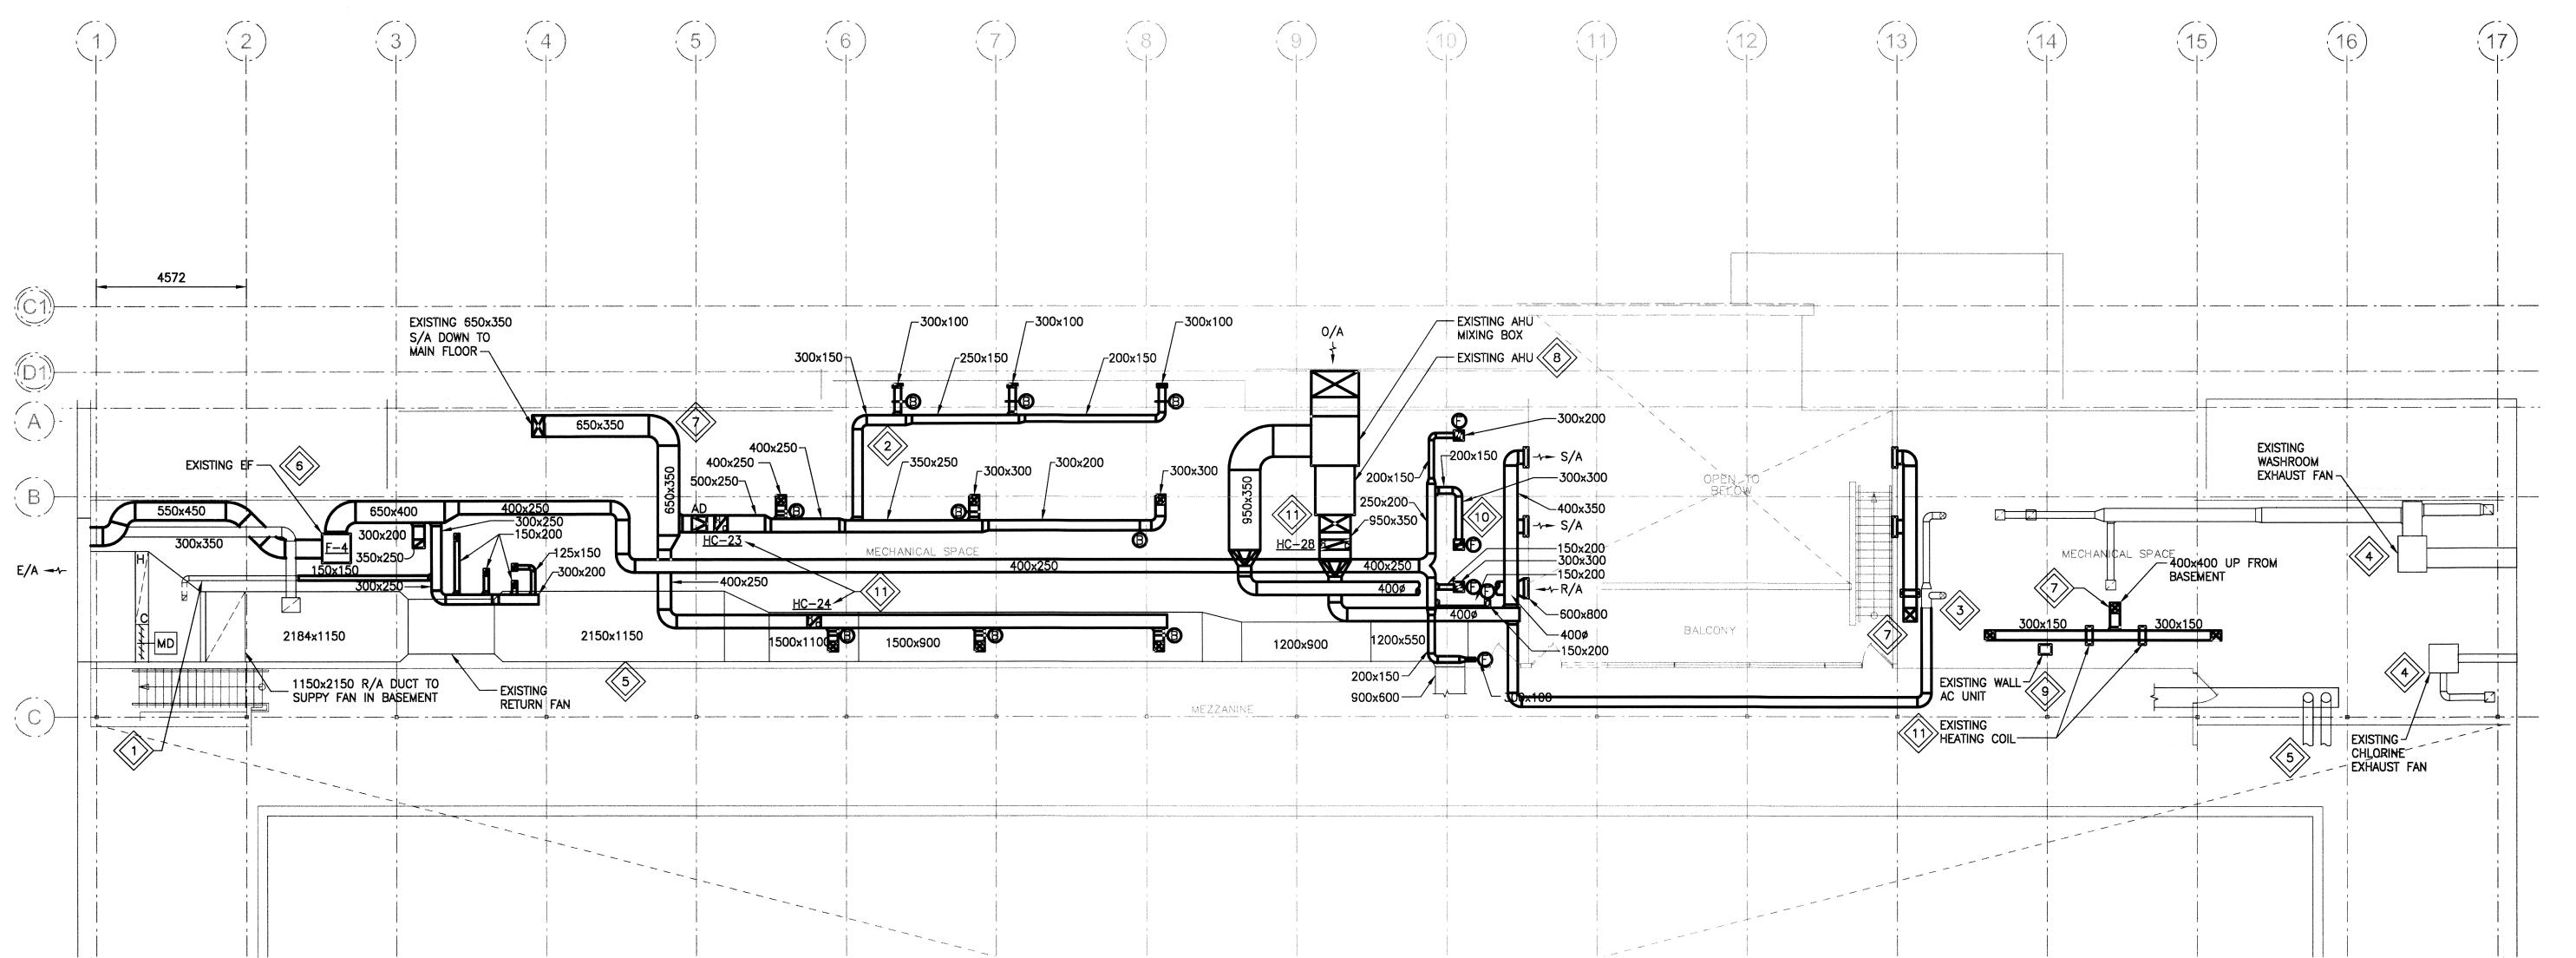

1 MEZZANINE PLAN - HVAC DEMO SCALE: 1:100

APEGIN Cartificate of Authorization KGS Group SCALE VERIFIED BY: _____ HC_

No. 245

Creating Sustainable Futures 300 - 141 Bannatyne Ave., Winnipeg, MB, R3B 0R3 telephone 204.956.0938 fax 204.943.5597 web www.prairiearchitects.ca GROUP CONSULTING ENGINEERS issue / rev. 2016/07/15 ISSUED FOR CONSTRUCTION # date issue notes professional seals project information SEVEN OAKS POOL SEVEN OAKS POO OVATION & ADDITIO 444 Adsum Drive Winnipeg, MB Canada

ARCHITECTS INC.

client

City of Winnipeg 4th Floor - 86 King Street

Winnipeg, MB

drawing information

MECHANICAL MEZZANINE FLOOR PLAN HVAC - DEMO drawn by:

approved b date issued: **2016.07.15**