


THE CITY OF WINNIPEG

WATER AND WASTE DEPARTMENT

SYNDICATE FLOOD PUMPING STATION UPGRADES

BID OPPORTUNITY No. 482-2018

SHT NO.	DRAWING NO.	DRAWING TITLE	CITY DRAWING NO
1 OF 7	A1	DEMOLITION FLOOR PLANS, CROSS SECTION	1-0189F-B0001-001
2 OF 7	A2	NEW CONSTRUCTION FLOOR PLANS, CROSS SECTIONS	1-0189F-B0002-001
3 OF 7	A3	NEW CONSTRUCTION SECTIONS, DETAILS, MISCELLANEOUS METALS	1-0189F-B0003-001
4 OF 7	M1	PLUMBING AND HVAC PLANS	1-0189F-M0001-001
5 OF 7	M2	DETAILS AND SCHEDULES	1-0189F-M0002-001
6 OF 7	E1	ELECTRICAL DEMOLITION	1-0189F-E0003-001
7 OF 7	E2	ELECTRICAL NEW CONSTRUCTION	1-0189F-E0004-001

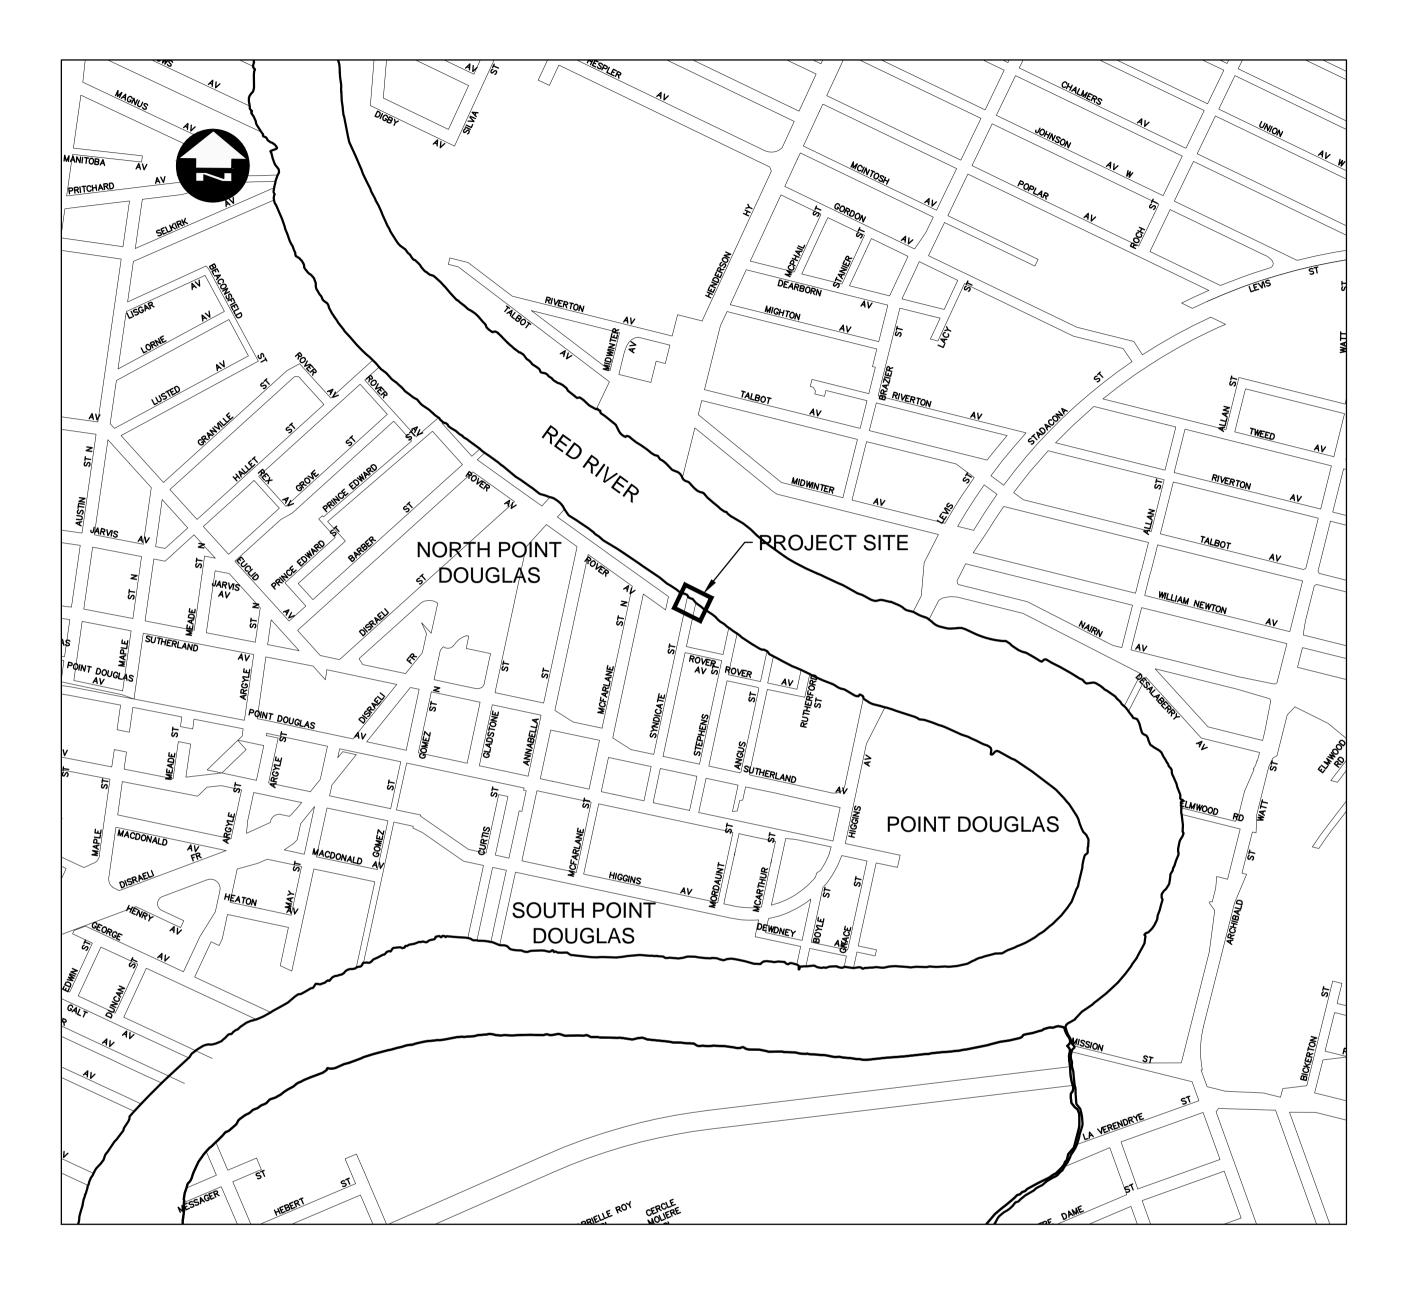



ISSUED FOR TENDER

SET NO.),
---------	----

