




GENERAL NOTES:


- THIS DRAWING IS DIAGRAMMATIC ONLY, DO NOT SCALE.
- PROVIDE CAP OR TEMPORARY SEAL ON ALL DOMESTIC SUPPLIES AND SANITARY LINES UNTIL LINES ARE READY TO BE CONNECTED TO FIXTURES.
- PROVIDE TRAP PRIMERS FOR ALL DRAINS WHICH ENCOUNTER LIMITED USE. IE. FLOOR DRAINS.
- 4. PROVIDE ISOLATION VALVES AT ALL GROUPS OF FIXTURES AND FIXTURE STOPS AT ALL
- 5. ALL PIPING MAINS ARE RUNNING IN THE PLENUM SPACE WITH BRANCH PIPING DROPPING DOWN TO FIXTURES.

DRAWING NOTES:

- 120 DOMESTIC COLD WATER SUPPLY AND 320 SANITARY PIPE TO DRINKING FOUNTAIN C/W SHUT-OFF VALVE.
- PROVIDE VERTICAL 50MM X 1200MM
 POLYSTYRENE INSULATION FROST BOX TO A
 MINIMUM DEPTH OF 2400MM.
- 3 PROVIDE 12MM HOSE CONNECTION WITH THREADED CAP ON CHAIN.
- 4 CONDENSATE PIPE FROM HRV.

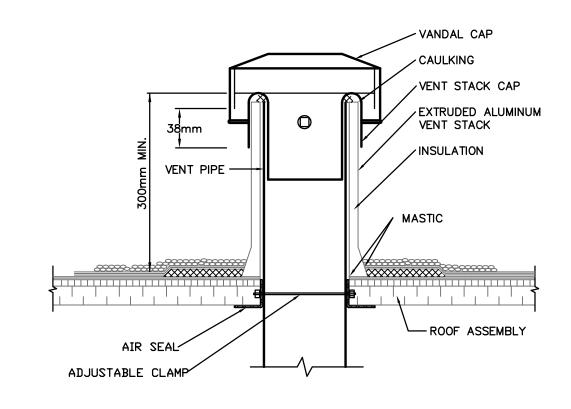

2 TYPICAL VENT THROUGH ROOF DETAIL M1.1 SCALE: NTS

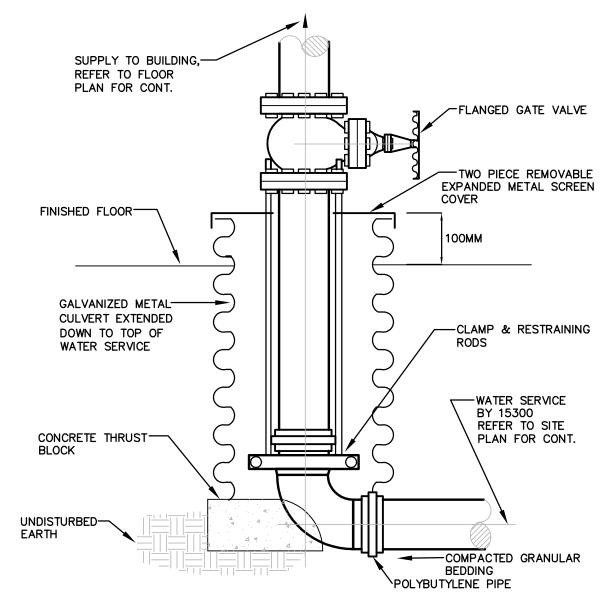

FROST BOX DETAIL

M1.1 SCALE: NTS

PLUMBING FIXTURE CONNECTION SIZES

FIXTURE DESCRIPTION	SANITARY CONNECTION		DOMESTIC COLD H ₂ 0 CONNECTION		DOMESTIC HOT H₂0 CONNECTION	
	INCHES	ММ	INCHES	ММ	INCHES	ММ
WATER CLOSET WITH FLUSH VALVE	3 STANDARD 4 W/ CARRIER	75 or 100	1	25		
URINAL	2	50	0.75	19		
LAVATORY	2	50	0.5	12	0.5	12
MOP SINK (FLOOR MOUNTED)	3	75	0.5	12	0.5	12
DRINKING FOUNTAIN	1.25	32	0.5	12		
HOSE BIBB			0.75	19		

Public City Architecture In

Public City Architecture Inc 707 Sara Avenue Winnipeg Manitoba R3G 0Y8 204 475 9323 publiccityarchitecture.com

Owner

City of Winnipeg 185 King Street, Winnipeg, Manitoba R3B 1J1 (204) 794-4418

No. Date Revision Notes

0 2018/07/27 Issued for Construction

10399 MCW

210-1821 Wellington Avenue
Winnipeg, Manitoba, R3H 0G4
Phone - (204) 779-7900 Fax - (204) 779-1119
E-Mail: mcw_wpg@mcw.com

Consulting Professional Engineers

Certificate of Authorization
MCW/AGE Consulting
Professional Engineers
No. 589

HIS IS A PRINT OF A DOCUMENT THAT HAS BEEN ELECTRONICALLY AUTHENTICATED WITH TECHNOLOGY AUTHORIZED BY THE APEGM. THE ORIGINAL IS IN ELECTRONIC FORM.



This drawing must not be scaled. The contractors shall verify all dimensions and other data on site prior to commencement of work. Discrepancies, errors, and omissions are to be reported to the Architect prior to proceeding with the Work.

Drawings and specifications as instruments of service are the property of the Architect; the copyright in the same being reserved to him.

No reproduction or revision to these drawings may be made without the permission of the Architect, and when made, must bear his name. All prints to be returned to the Architect upon request.

Project

Crescent Drive Park Pavilion

MAIN FLOOR
PLUMBING PLAN

July 2018

Drawn By

KL

Scale
As Noted

Drawing No.

M1.1

Date

Project No.

Revision No.