
GENERAL NOTES:

- 1. ELECTRICAL DRAWINGS ARE DIAGRAMMATICAL ONLY AND ARE NOT TO BE USED FOR FINAL MEASUREMENTS. THE ELECTRICAL SUB-CONTRACTOR SHALL FIELD-VERIFY EXACT LOCATIONS AND DISTANCES ON-SITE PRIOR TO BID.
- 2. NOT ALL EXISTING UNDERGROUND UTILITIES ARE SHOWN ON THE SITE PLAN. IT IS THE ELECTRICAL SUB-CONTRACTORS RESPONSIBILITY TO VERIFY AND PERFORM UNDERGROUND LINE LOCATES TO CONFIRM ALL EXISTING UNDERGROUND SERVICES PRIOR TO COMMENCEMENT OF ANY GROUND WORK. REPORT ANY DISCREPANCIES OR ISSUES TO ENGINEER..
- 3. ALL NEW FEEDERS SHALL BE PUSHED AT 1m DEPTH UNLESS A DEEPER DEPTH IS REQUIRED TO AVOID OBSTACLES. ELECTRICAL SUB-CONTRACTOR TO EXCAVATE AS REQUIRED AND RESTORE THE SURFACES TO MATCH EXISTING. THE CONTRACTOR SHALL INSTALL UNDERGROUND FEEDERS WITH SUFFICIENT SLACK TO PREVENT SHEERING

KEYNOTES:


- ELECTRICAL SUB-CONTRACTOR TO ALLOW FOR EXCAVATING AND HYDRO VACUUMING AREAS WHERE UTILITIES ARE EXPECTED TO CROSS WITH KNOWN UNDERGROUND UTILITIES.
- 2 ELECTRICAL SUB-CONTRACTOR SHALL PROVIDE A FIBERGLASS PAD TO MOUNT THE TRANSFORMER.

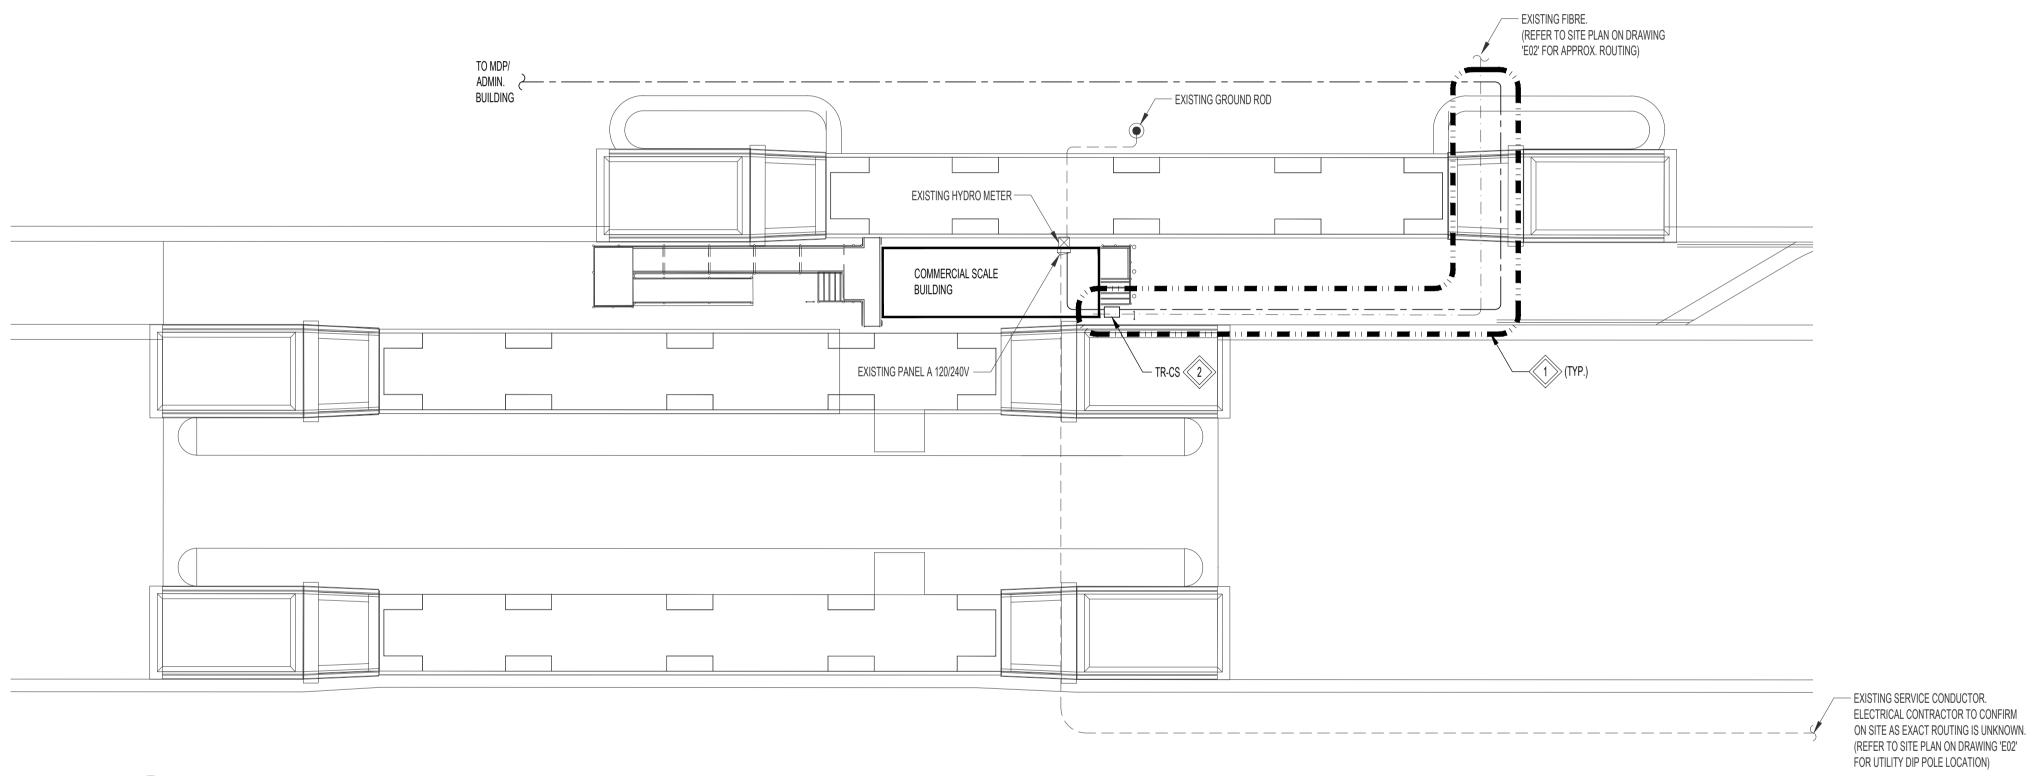

COMMERCIAL SCALE BUILDING - NEW

ENGINEERS
GEOSCIENTISTS **MANITOBA Certificate of Authorization** KGS Group SCALE: 1:150mm (24"x36") No. 245

LOCATION APPROVED UNDERGROUND STRUCTURES	
SUPV. U/G STRUCTURES DATE	
NOTE: LOCATION OF UNDERGROUND STRUCTURES AS	
SHOWN ARE BASED ON THE BEST INFORMATION AVAILABLE BUT NO GUARANTEE IS GIVEN THAT ALL EXISTING UTILITIES ARE SHOWN OR THAT THE GIVEN LOCATIONS ARE EXACT.	
CONFIRMATION OF EXISTENCE AND EXACT LOCATION OF ALL SERVICES MUST BE OBTAINED FROM THE INDIVIDUAL UTILITIES	
BEFORE PROCEEDING WITH CONSTRUCTION.	Z

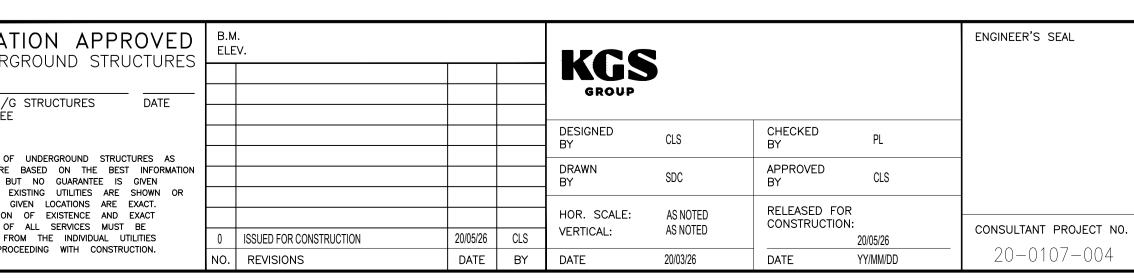



THE CITY OF WINNIPEG WATER AND WASTE DEPARTMENT

BRADY ROAD LANDFILL STANDBY GENERATOR

COMPUTER FILE NAME CONSULTANT DRAWING NUMBER

SHEET

COMMERCIAL SCALE BUILDING